

DESCRIPTION	SHEET NO.
TITLE PAGE	1
SEWER PLAN & PROFILE	2
SEWER FORCE MAIN PLAN	3
SEWER FORCE MAIN PROFILE	4
SEWER PUMP STATION PLAN & DETAILS	5
WATER SYSTEM PLANS & DETAILS FACILITIES, POWER & CONTROL SCHEMATICS	6


STATE OF VERMONT
 AGENCY OF TRANSPORTATION



PROPOSED IMPROVEMENT

RUTLAND STATE AIRPORT

WATER AND SEWER FACILITIES

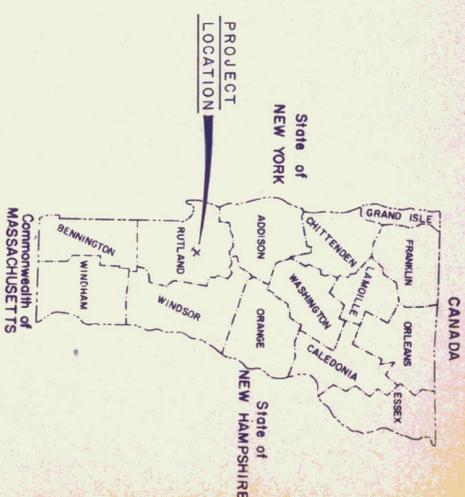

CONVENTIONAL SIGNS

COUNTY LINE	---
TOWN LINE	----
LIMITS OF ACCESS	—○—○—○—
POINT OF ACCESS	X
FENCE LINE	—x—x—x—
STONE WALL	—x—x—x—
TRAVELED WAY	—x—x—x—
GUARD RAIL	—x—x—x—
RAILROAD	—x—x—x—
SURVEY LINE	—x—x—x—
CULVERT	—x—x—x—
POWER POLE	—x—x—x—
TELEPHONE POLE	—x—x—x—
TREES	—x—x—x—
CONTROL OF ACCESS	—x—x—x—
PROPERTY LINE	—x—x—x—
R.O.W TAKING LINE	—x—x—x—
SLOPE RIGHTS	—x—x—x—
TOP OF CUT	—x—x—x—
TOE OF SLOPE	—x—x—x—

DATUM	
VERTICAL	NGVD
HORIZONTAL	

These plans are subject to such engineering changes as may be required by the Federal Highway Administration or the Director of Engineering and Construction.

Construction is to be carried on in accordance with these plans and the Standard Specifications for Highway and Bridge Construction dated March, 1976, as approved by the Federal Highway Administration on October 27, 1976 for use on this project, including all subsequent revisions and such revised specifications and special provisions as are incorporated in these plans.

FOR APPROVAL

AUG 1 1984

COPY NO. 3

SUBMITTED BY ORDER OF THE STATE TRANSPORTATION BOARD


APPROVED: _____ DATE _____

DIRECTOR OF ENGINEERING AND CONSTRUCTION
 DEPARTMENT OF TRANSPORTATION
 FEDERAL HIGHWAY ADMINISTRATION

APPROVED: _____ DATE _____

DIVISION ADMINISTRATOR

PROJECT _____

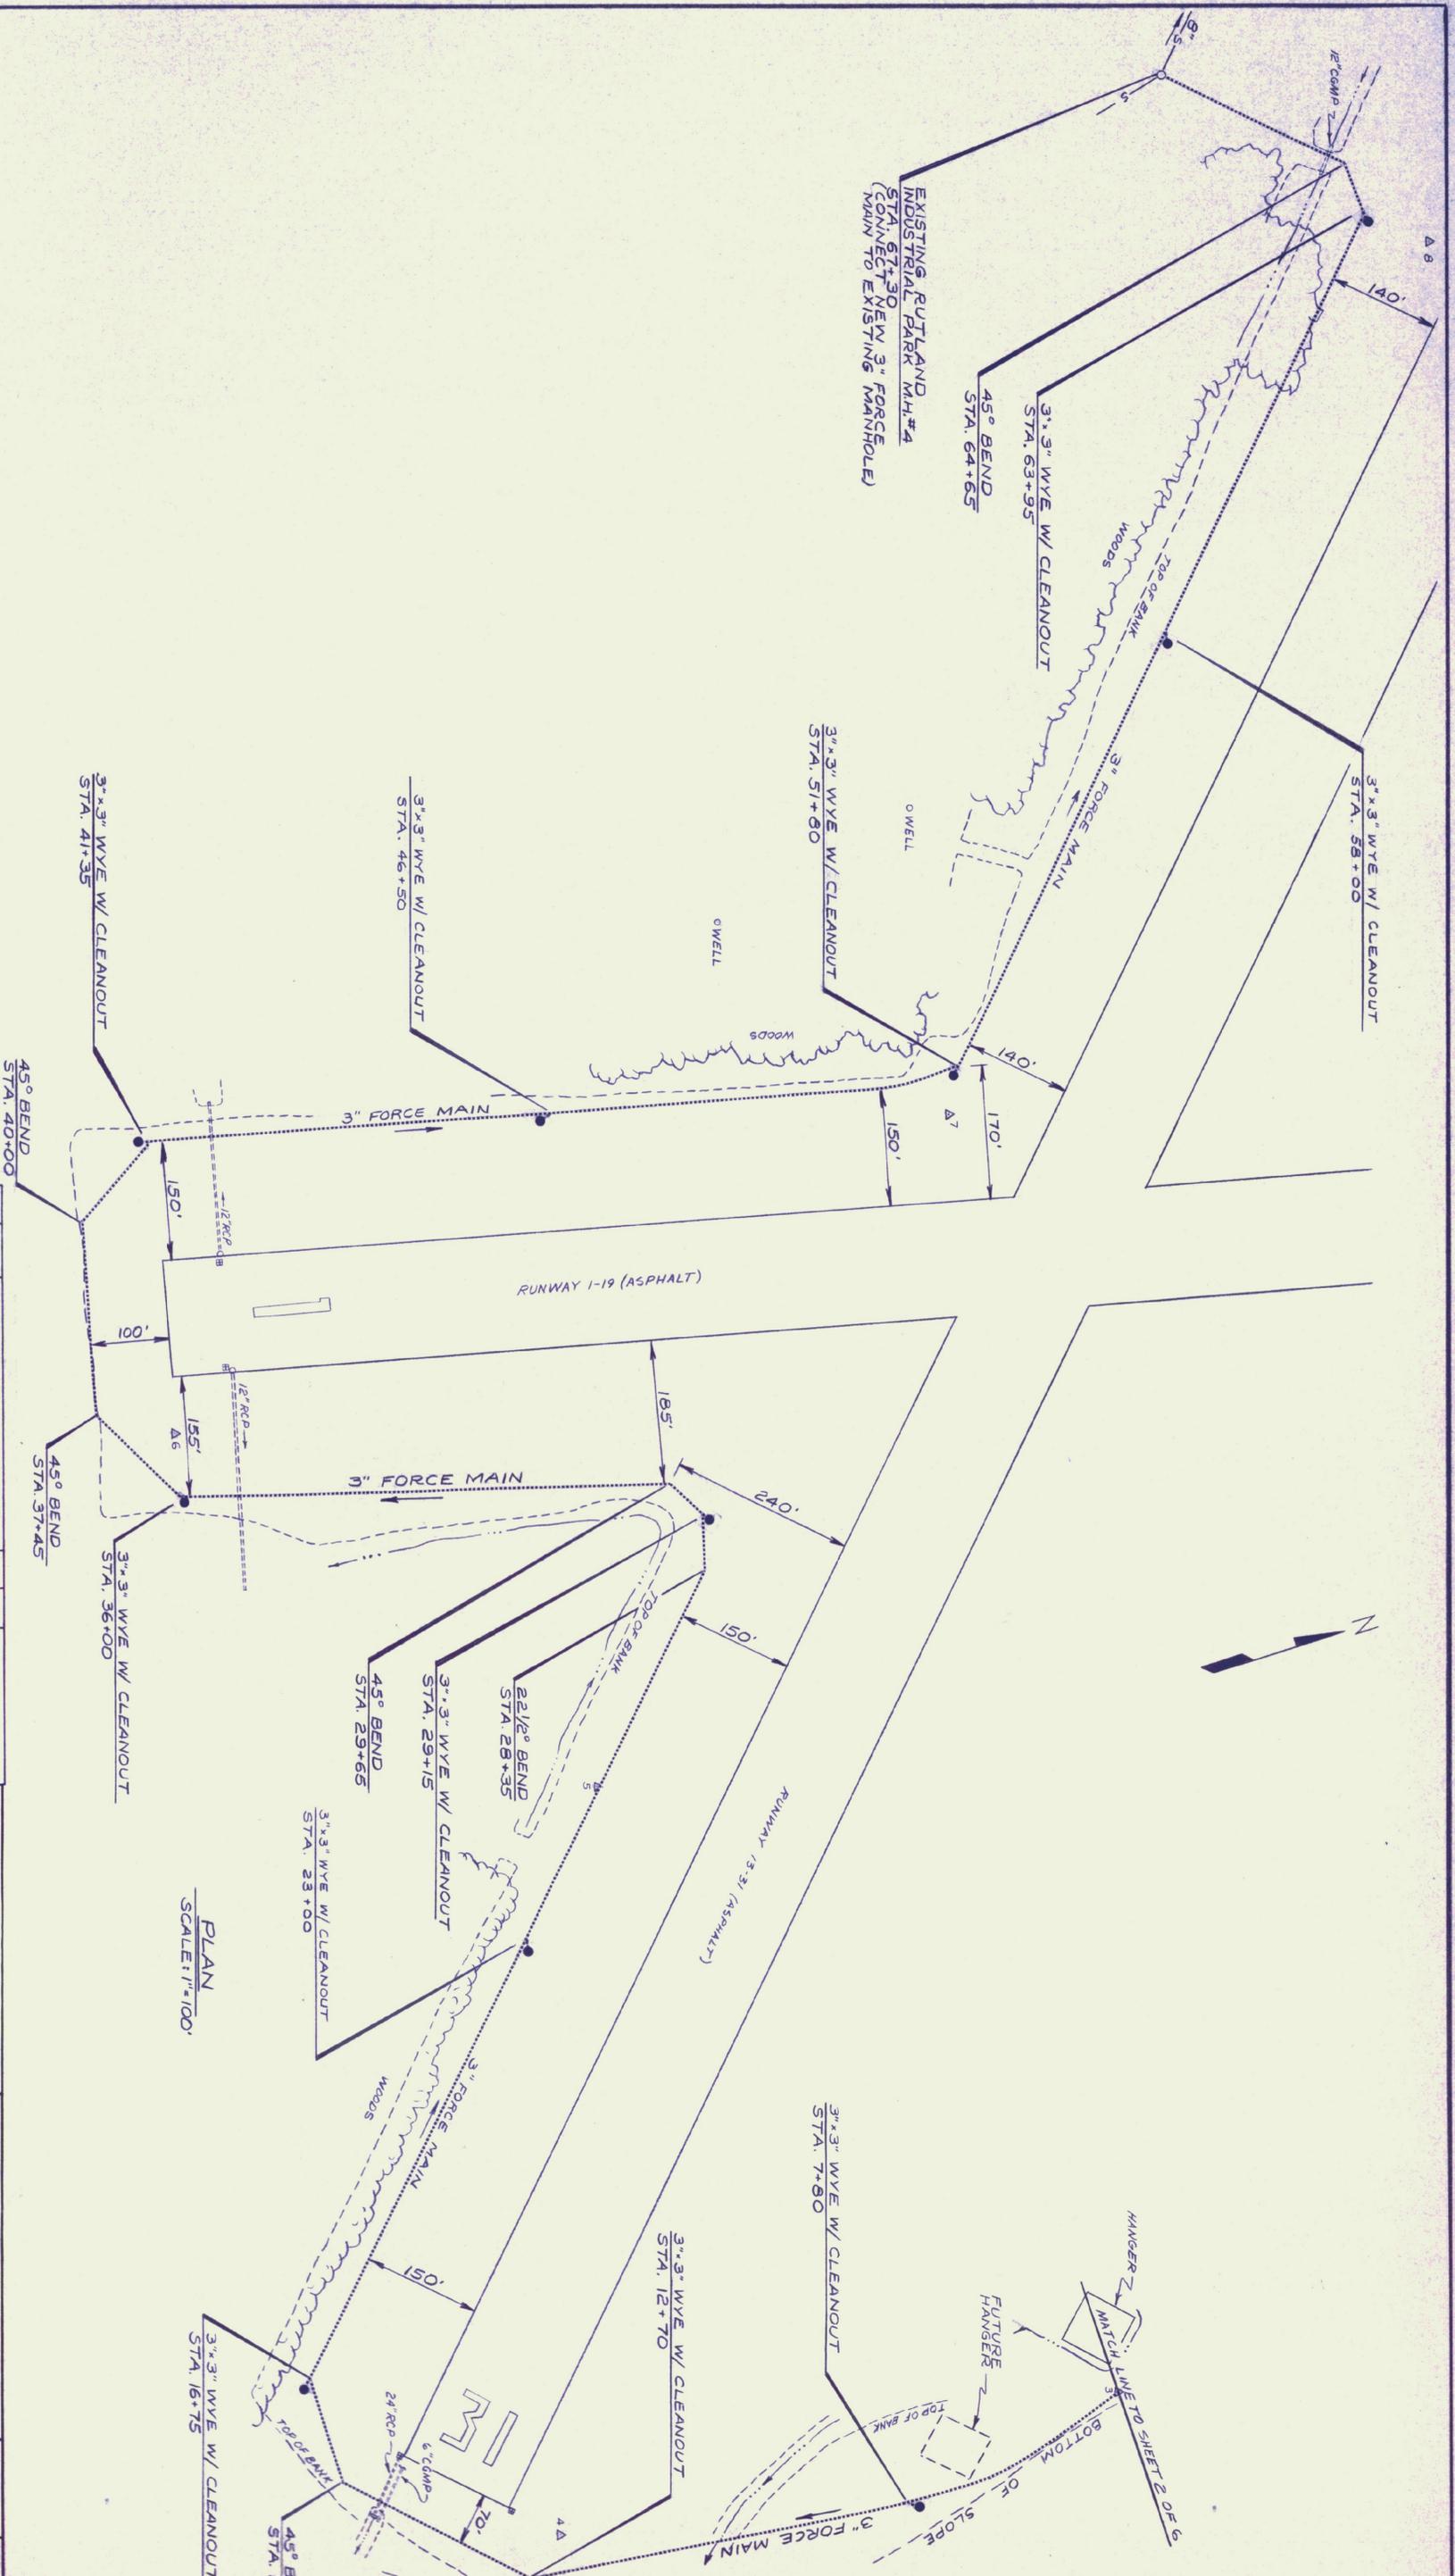

PLAN
SCALE: 1"=100'


NO.	DATE	REVISIONS	BY	CK'D



DuBois & King Inc.
 engineering
 planning
 management
 development

STATE OF VERMONT
 AGENCY OF TRANSPORTATION
 RUTLAND STATE AIRPORT
 SEWER FORCE MAIN
 PLAN

DRAWN BY	DATE
ECS, RFO	6/21/84
CHECKED BY	PROJ. NO.
<i>[Signature]</i>	45703
PROJ. ENG.	DRAW. NO.
EJC	5355
SHEET 3 OF 6	

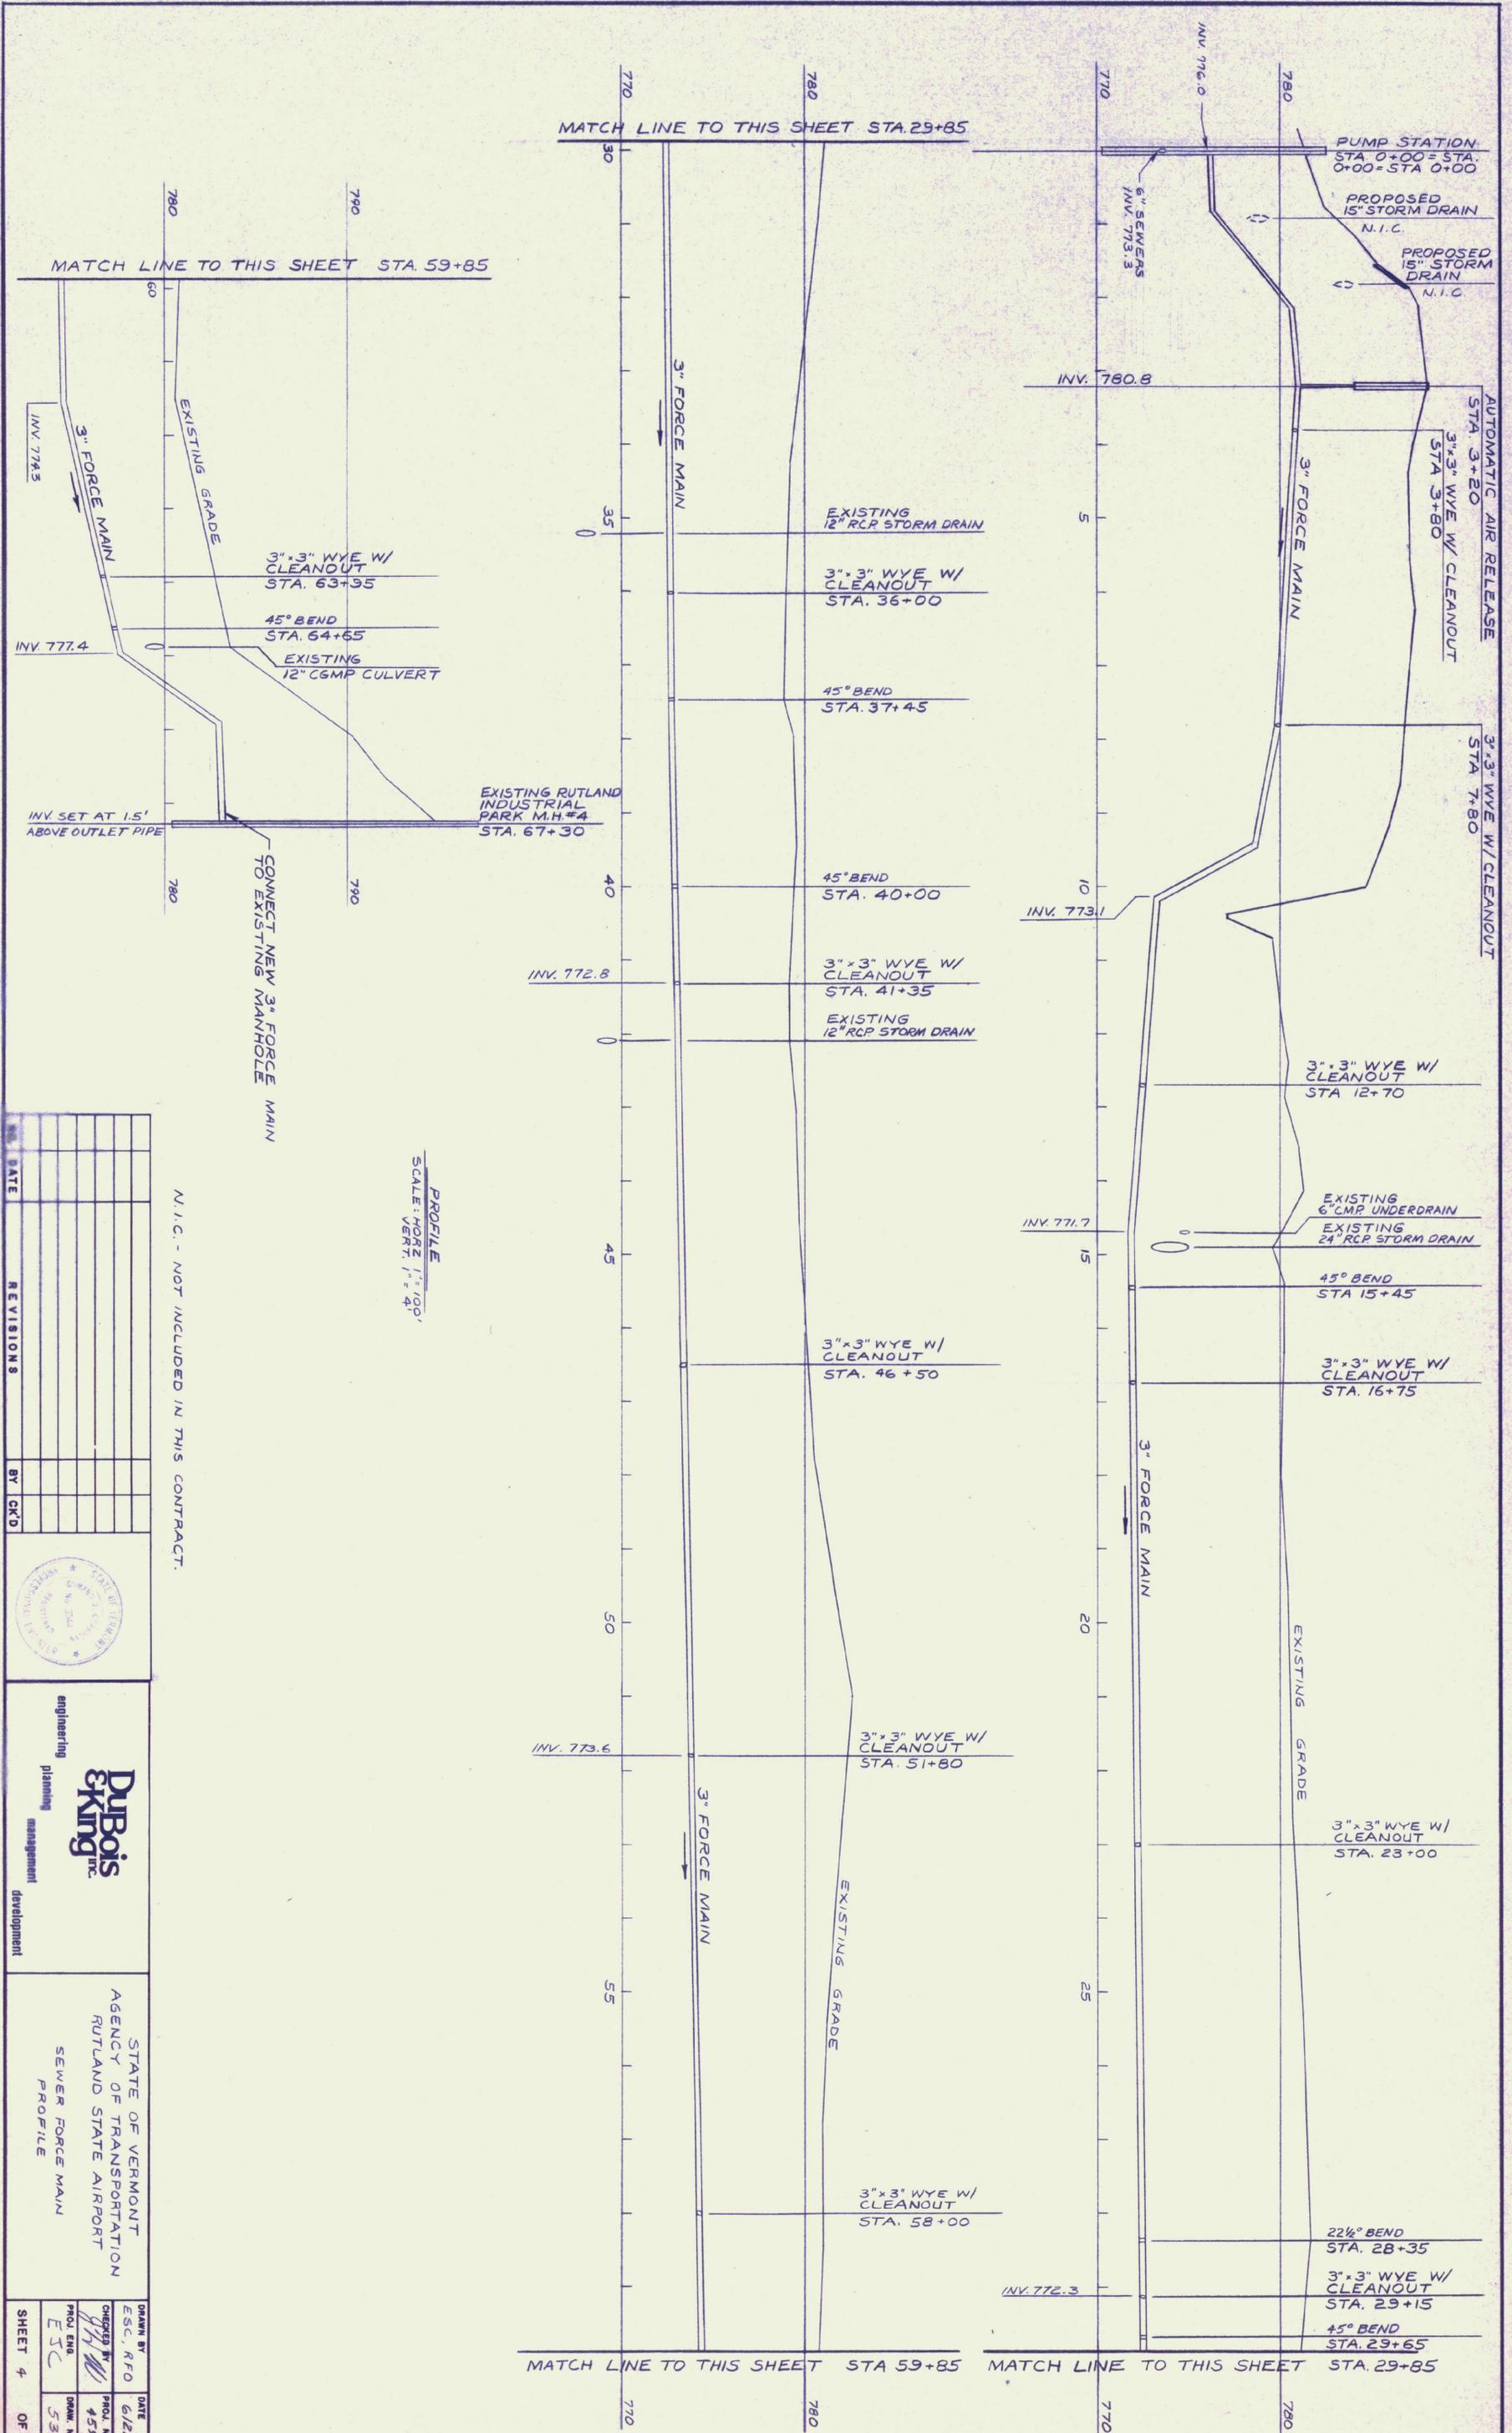

PROFILE
SCALE: HORIZ. 1" = 100'
VERT. 1" = 4'

N.I.C. - NOT INCLUDED IN THIS CONTRACT.

NO.	DATE	REVISIONS	BY















engineering
planning
management
development

DuBois & King Inc.

STATE OF VERMONT
AGENCY OF TRANSPORTATION
RUTLAND STATE AIRPORT
SEWER FORCE MAIN
PROFILE

DRAWN BY ESC, RFD	DATE 6/22/84
CHECKED BY EJC	PROJ. NO. 45703
PROJ. ENG. EJC	DRAW. NO. 5356
SHEET 4	OF 6

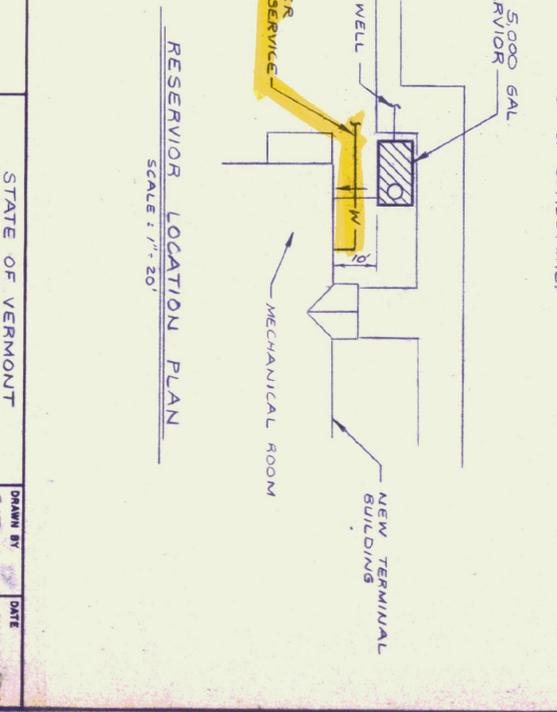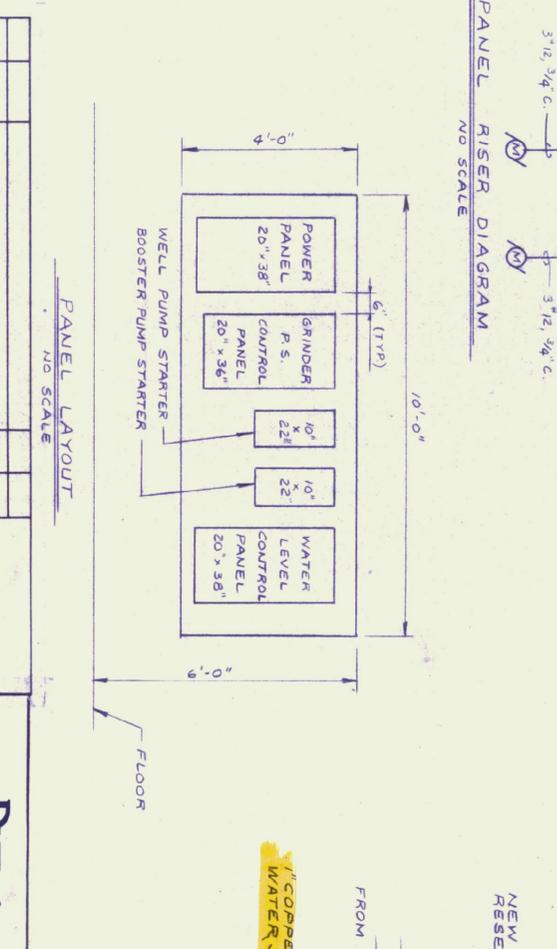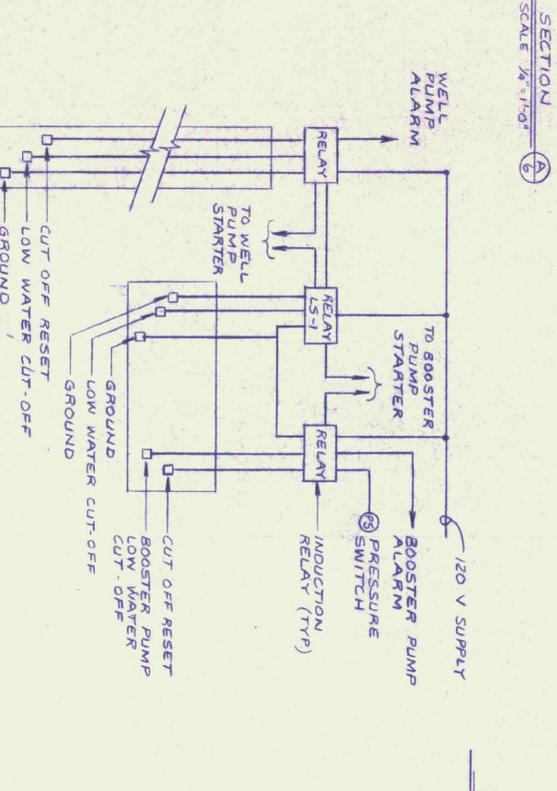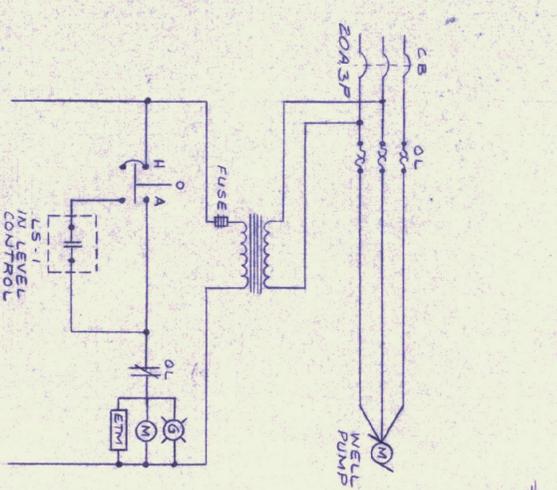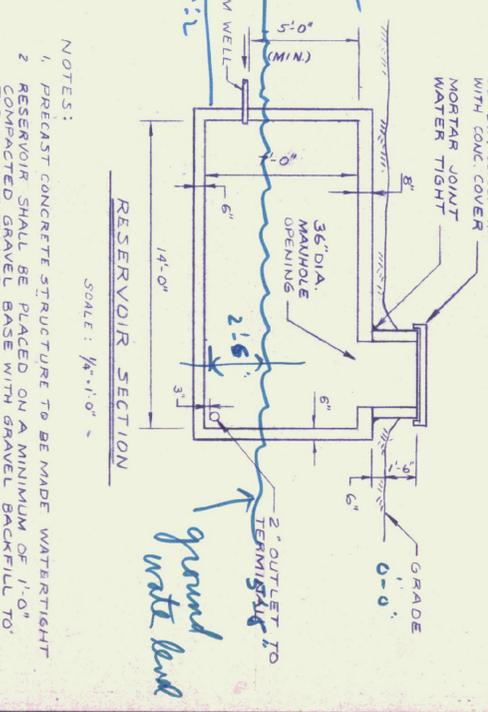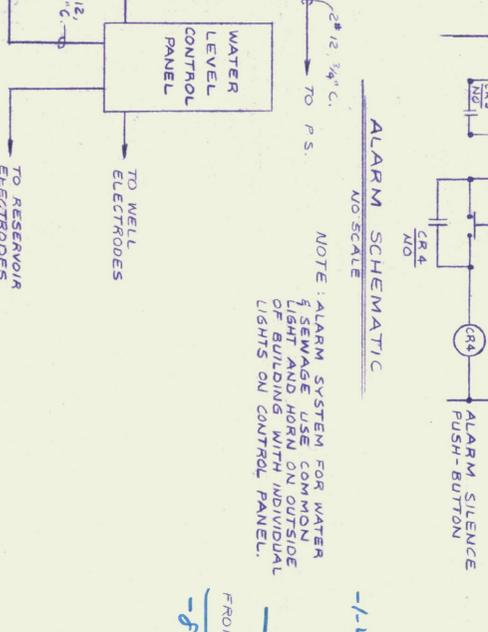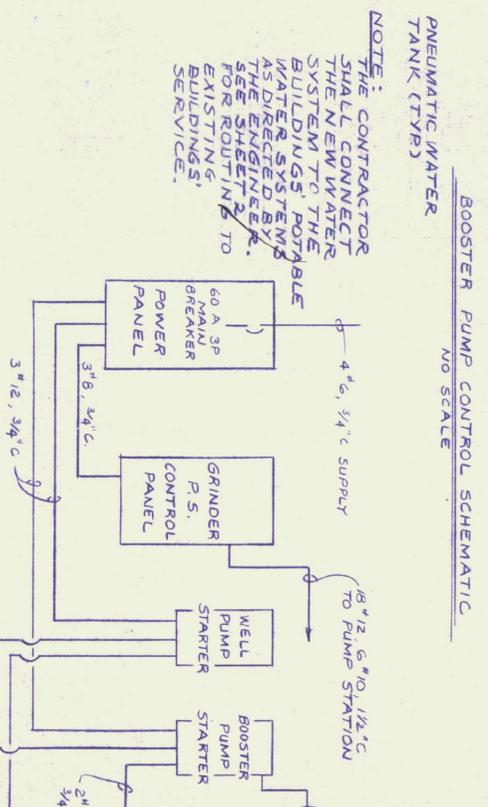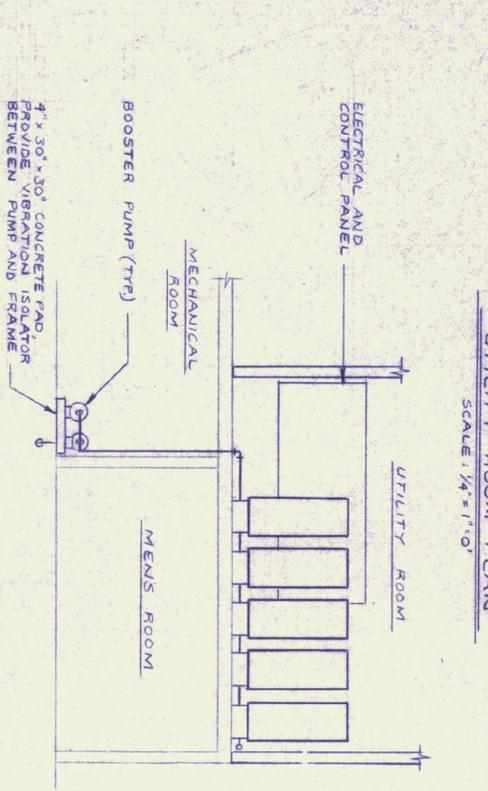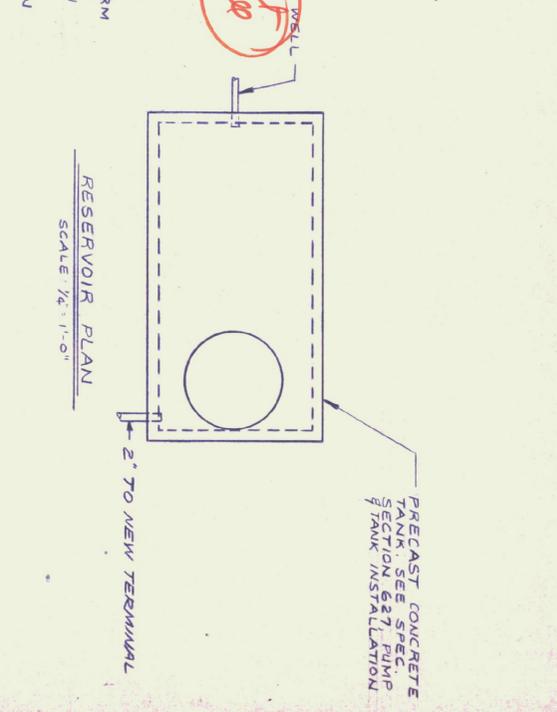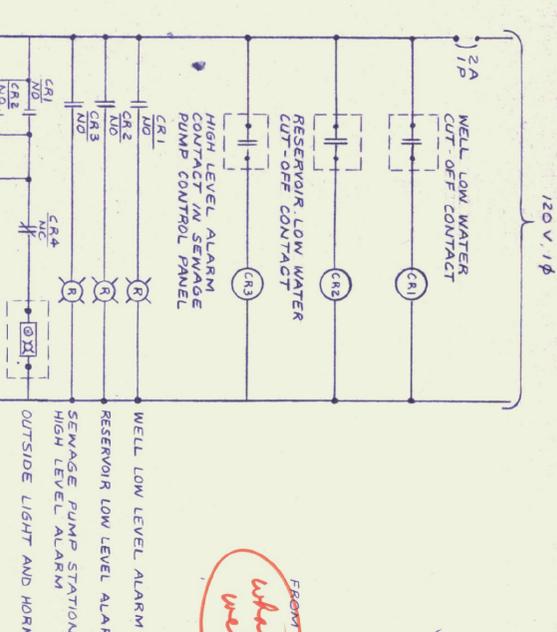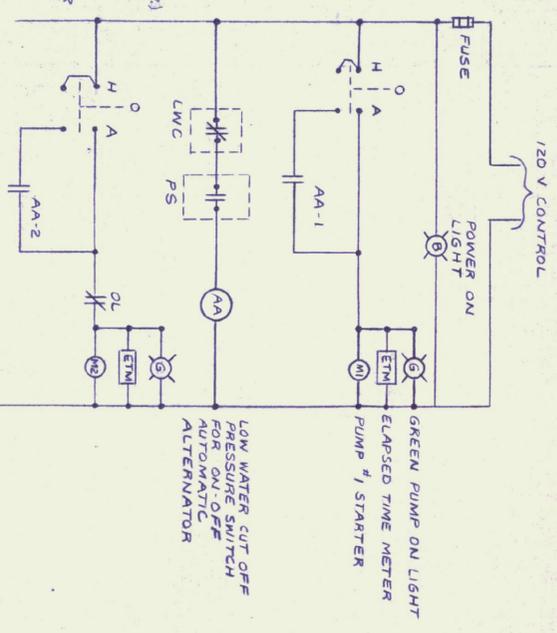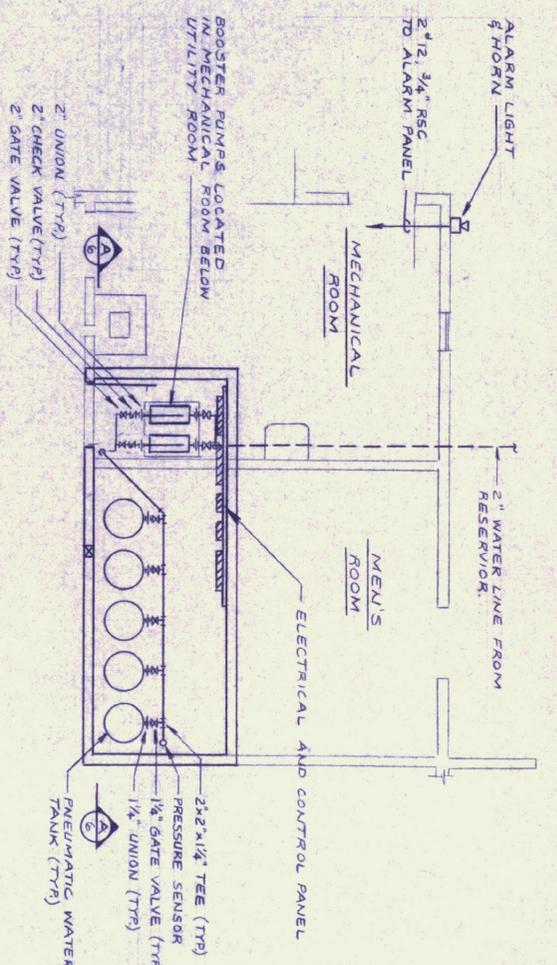

NO.	DATE	REVISIONS	BY	CR/D

STATE OF VERMONT
AGENCY OF TRANSPORTATION
RUTLAND STATE AIRPORT
WATER SYSTEM
PLANS AND DETAILS
FACILITIES, POWER AND
CONTROL SCHEMATICS

DuBois & King Inc.
engineering
planning
management
development

DRAWN BY: SJT
CHECKED BY: [Signature]
PROJ. NO.: 45903
PROJ. ENG.: E.S.C.
DATE: JULY 1984
SHEET 6 OF 6