




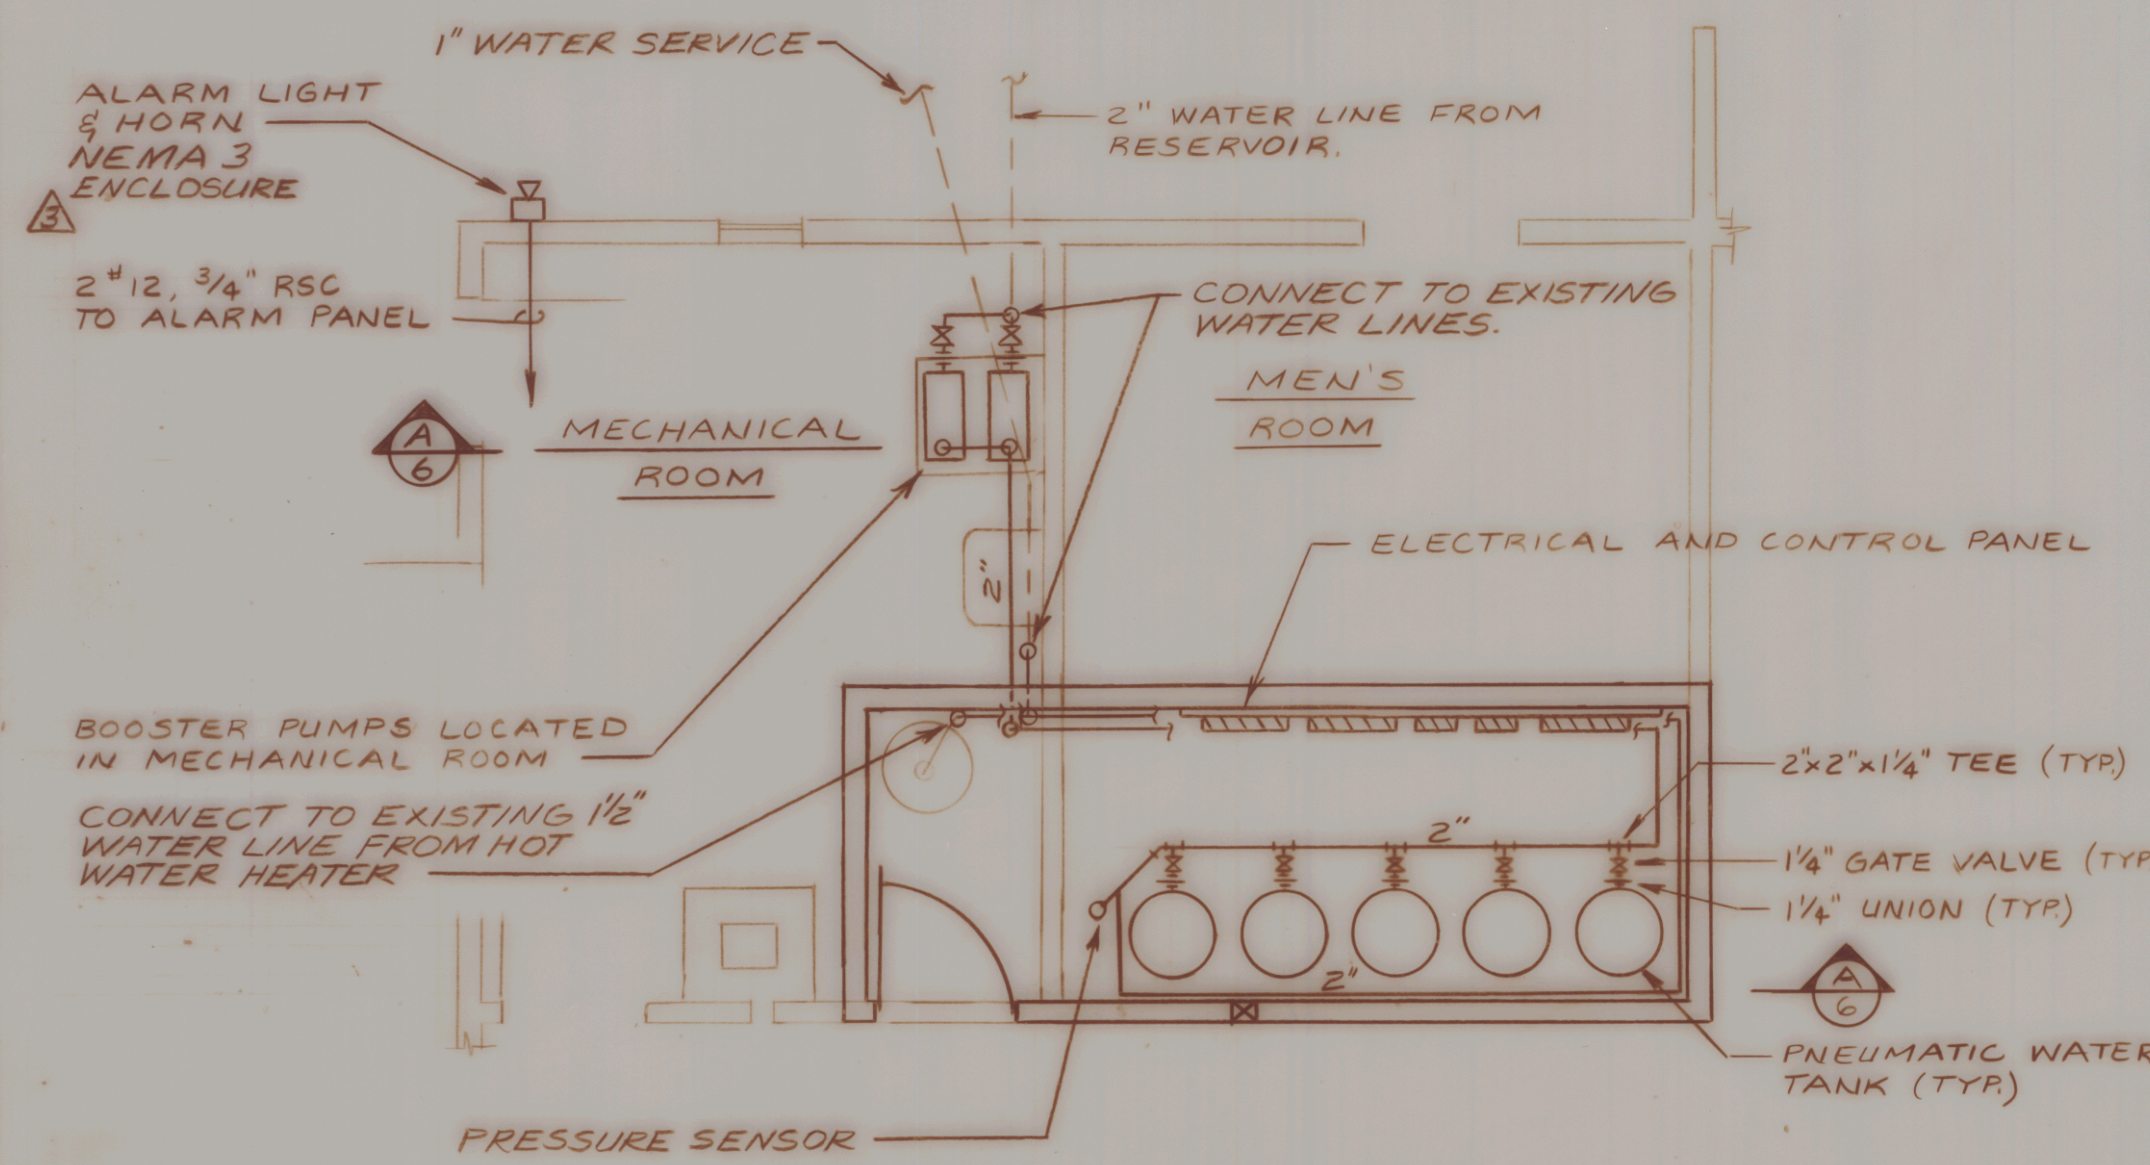


UTILITY ROOM PLAN
SCALE: 1/4" = 1'-0"

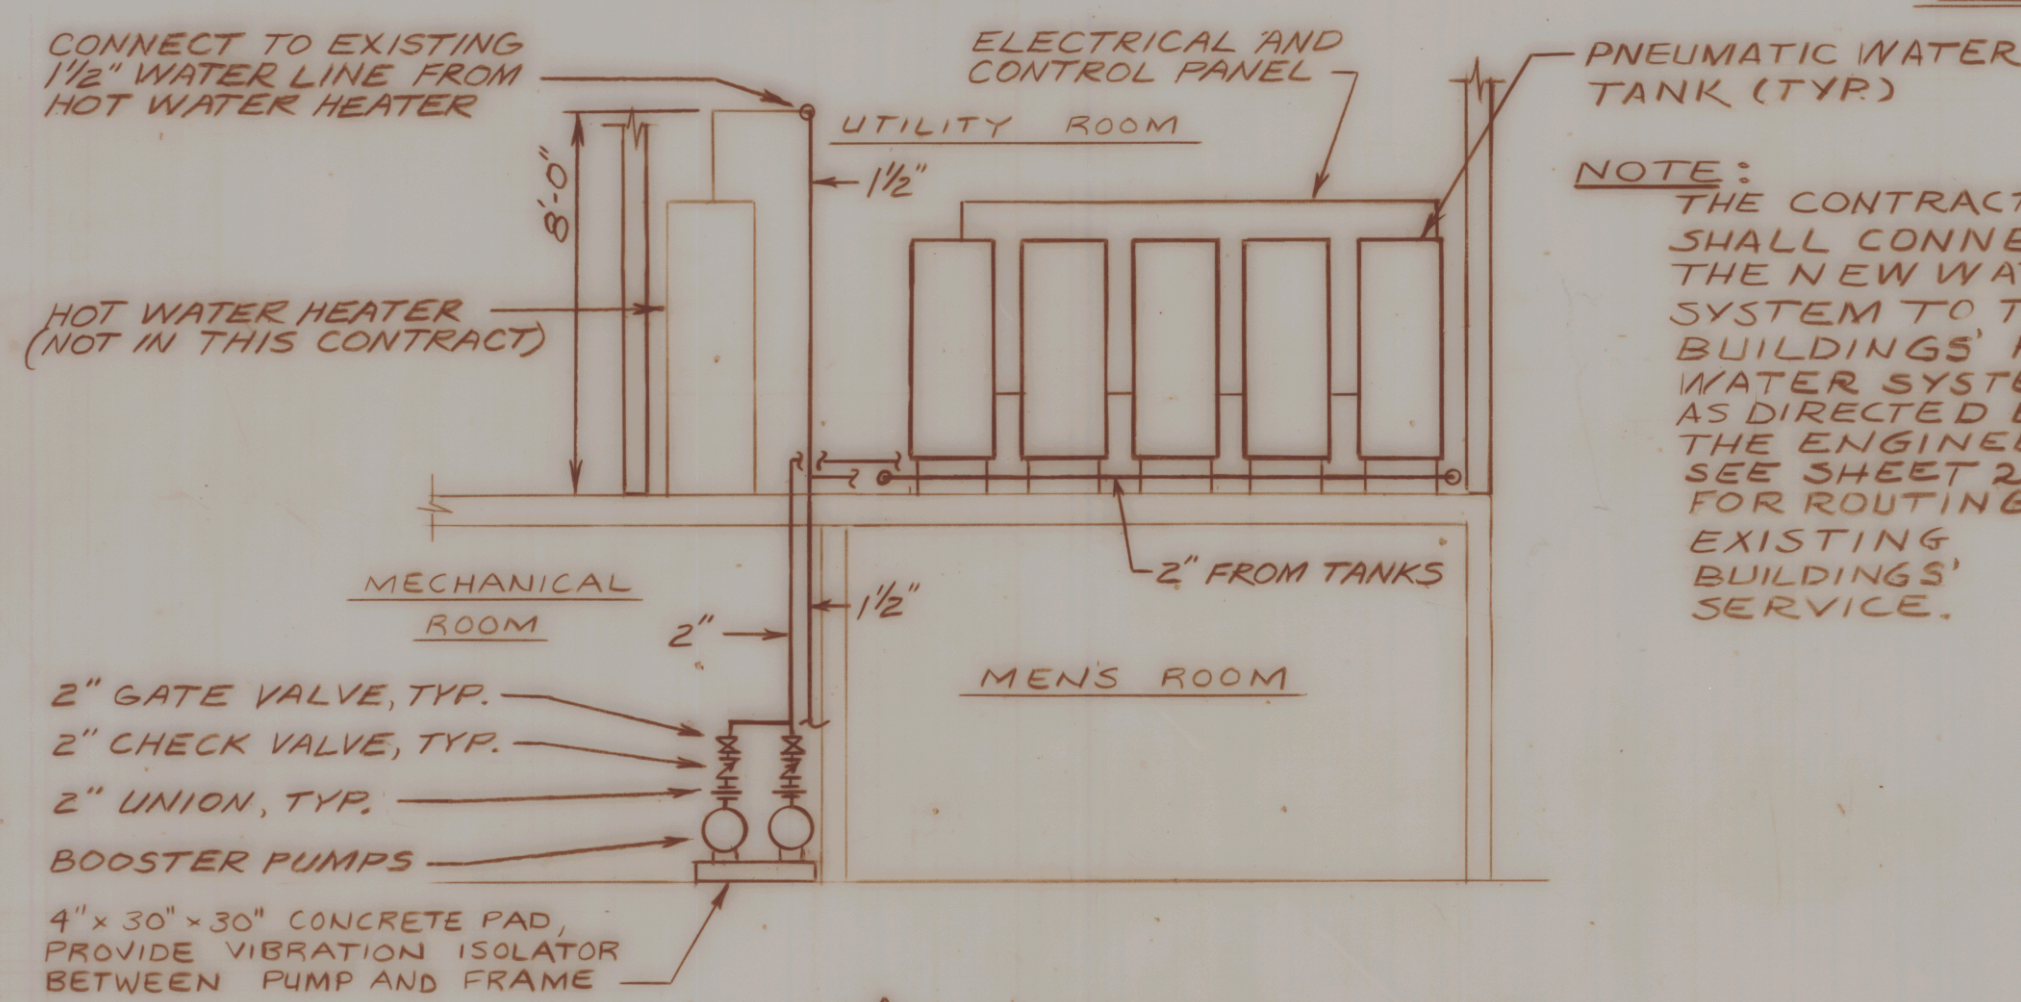


SECTION
SCALE: 1/4" = 1'-0"

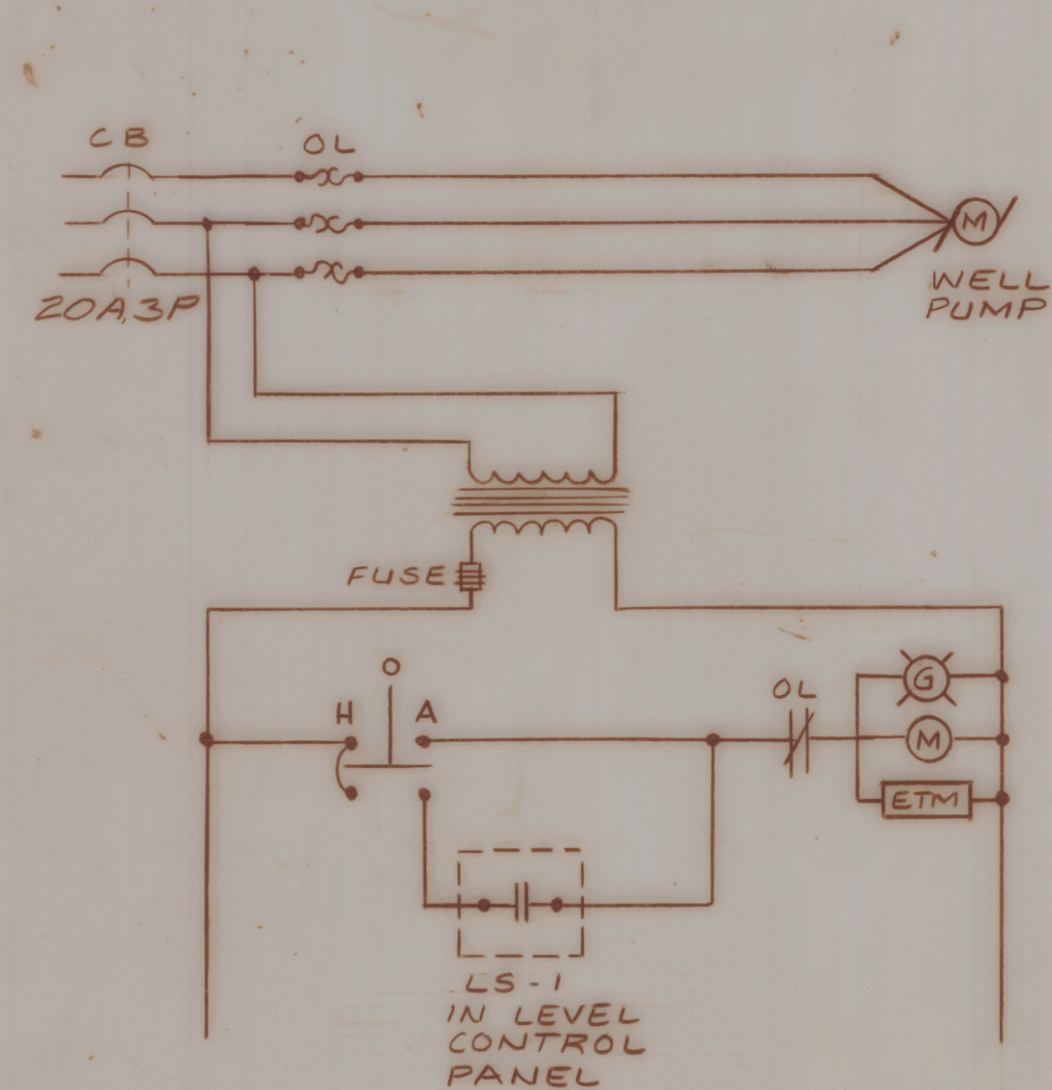


WELL PUMP CONTROL SCHEMATIC
NO SCALE

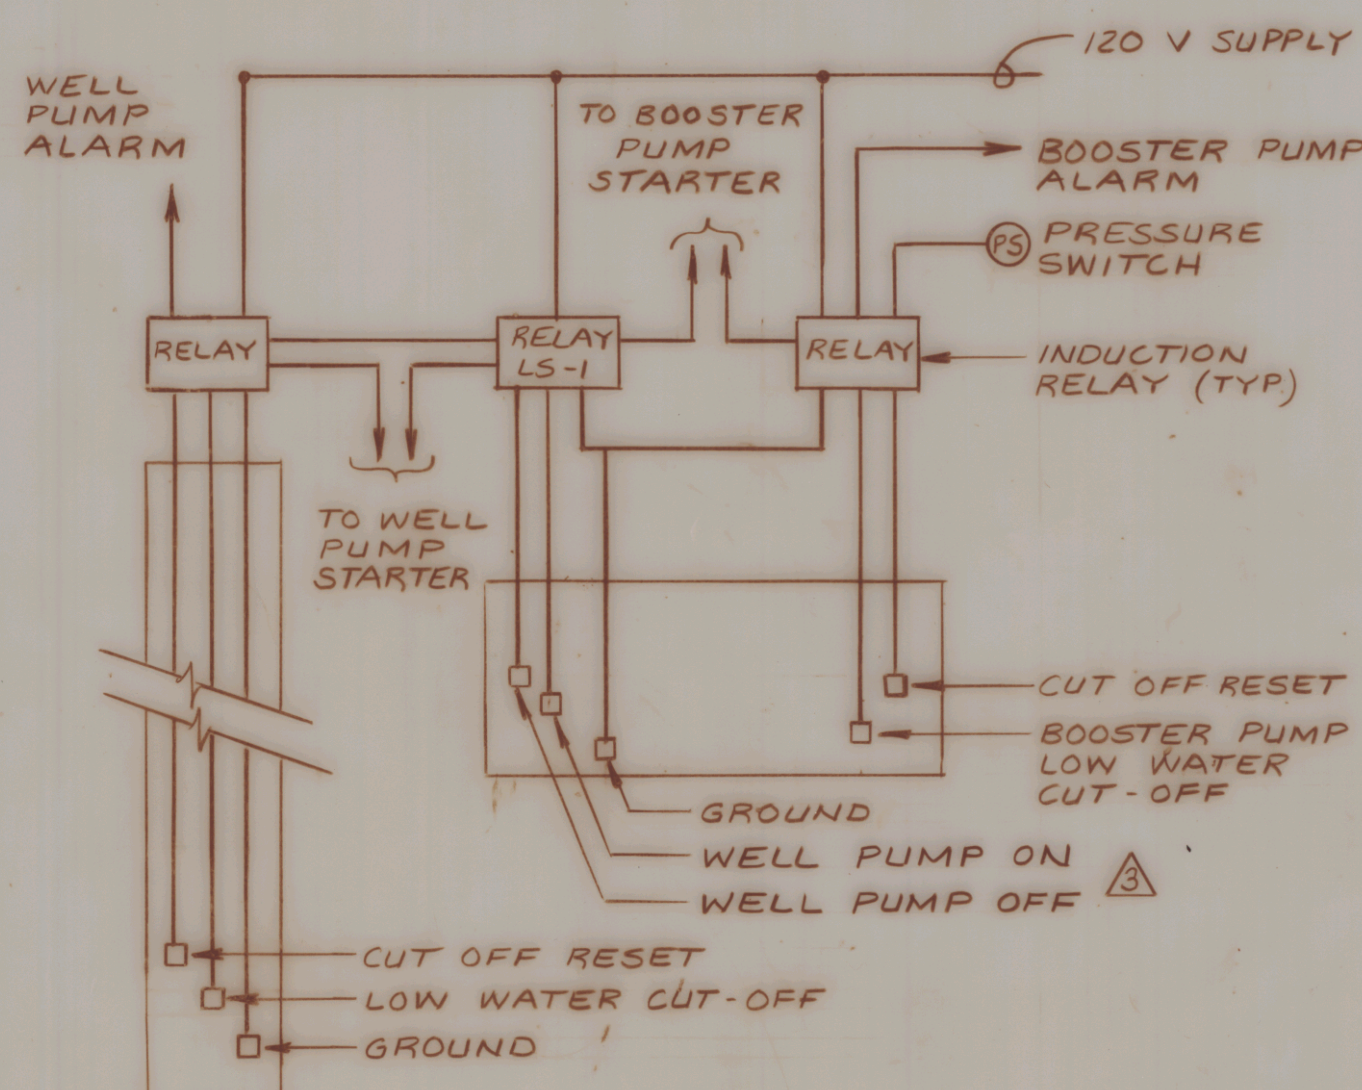


LEVEL CONTROL DIAGRAM
NO SCALE

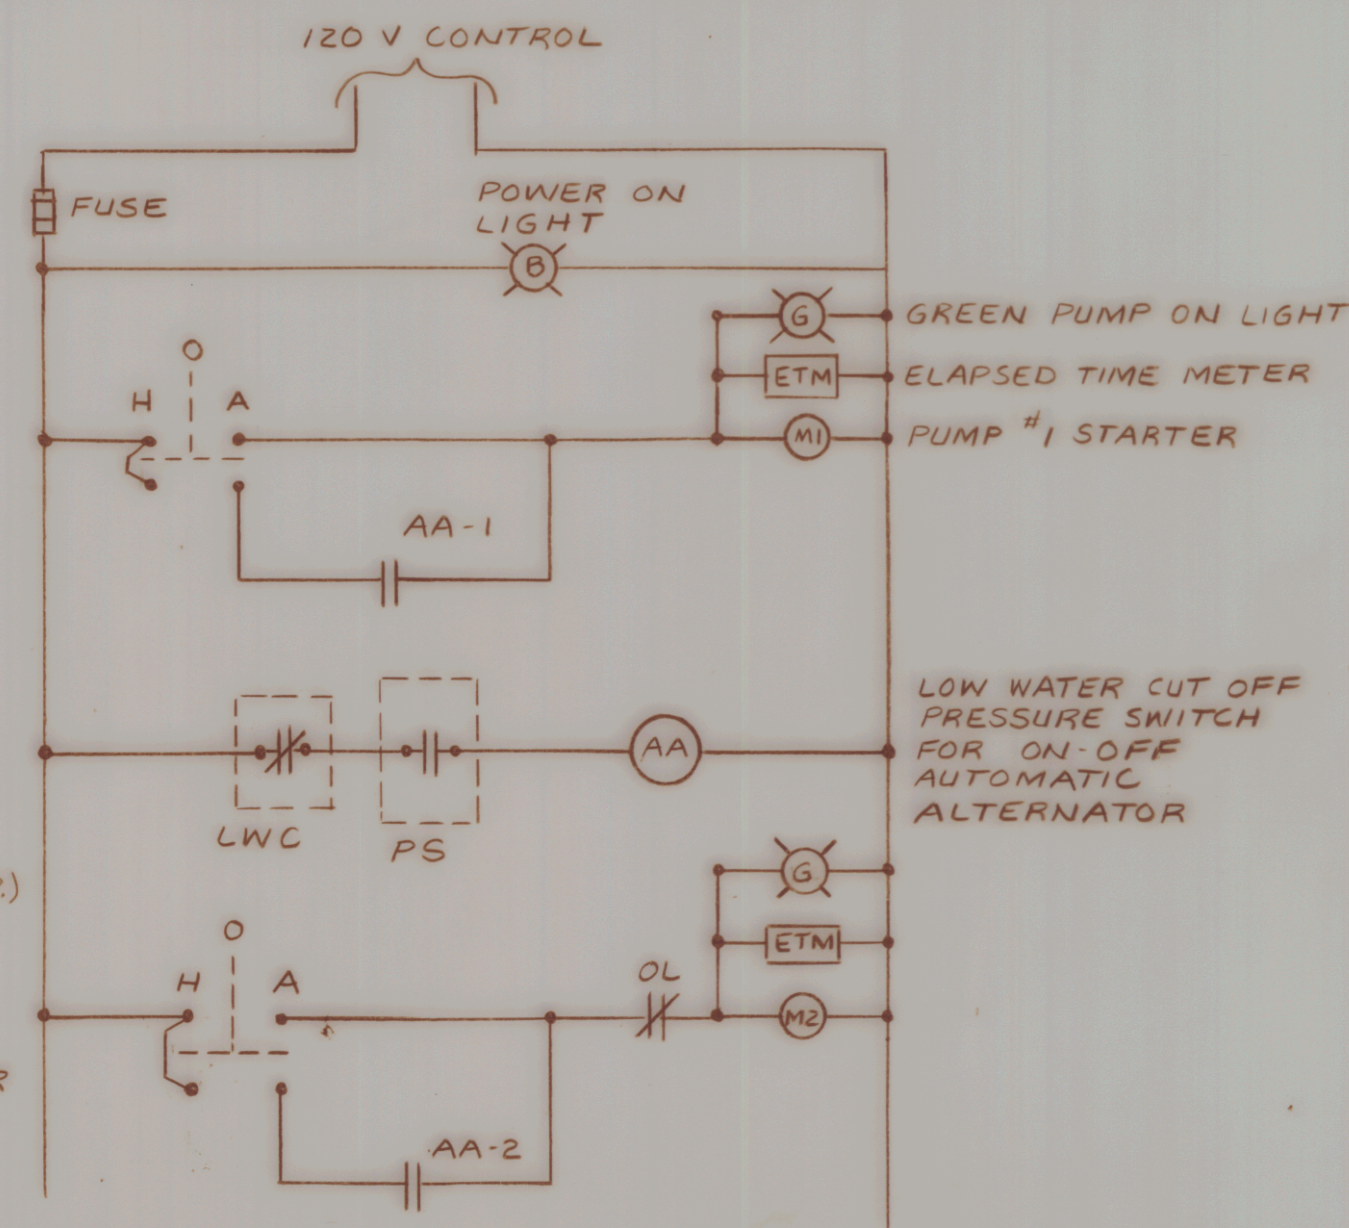


BOOSTER PUMP CONTROL SCHEMATIC
NO SCALE

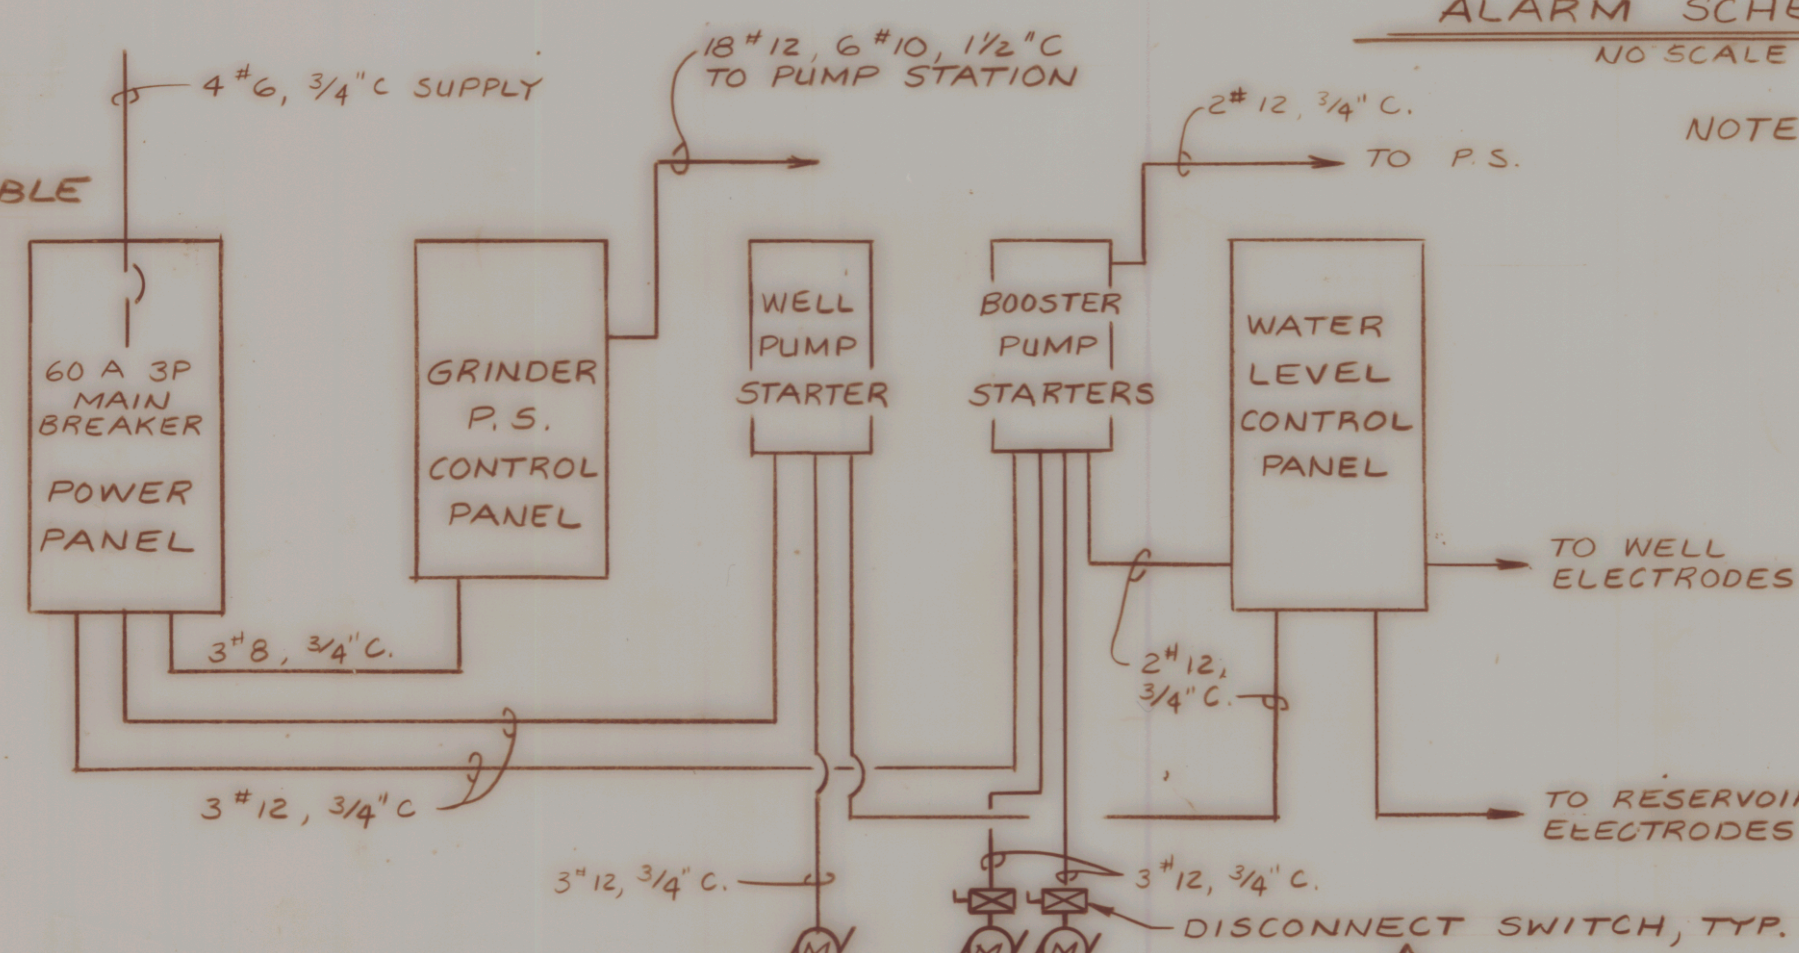

PANEL RISER DIAGRAM
NO SCALE

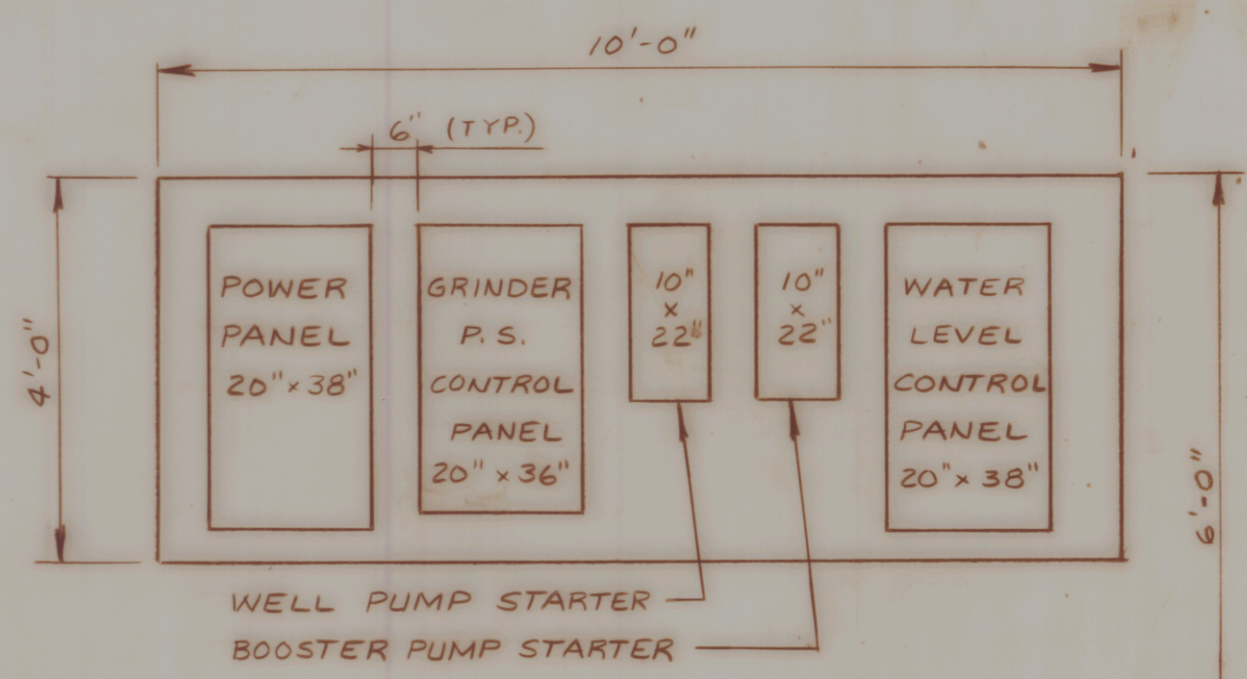


PANEL LAYOUT
NO SCALE

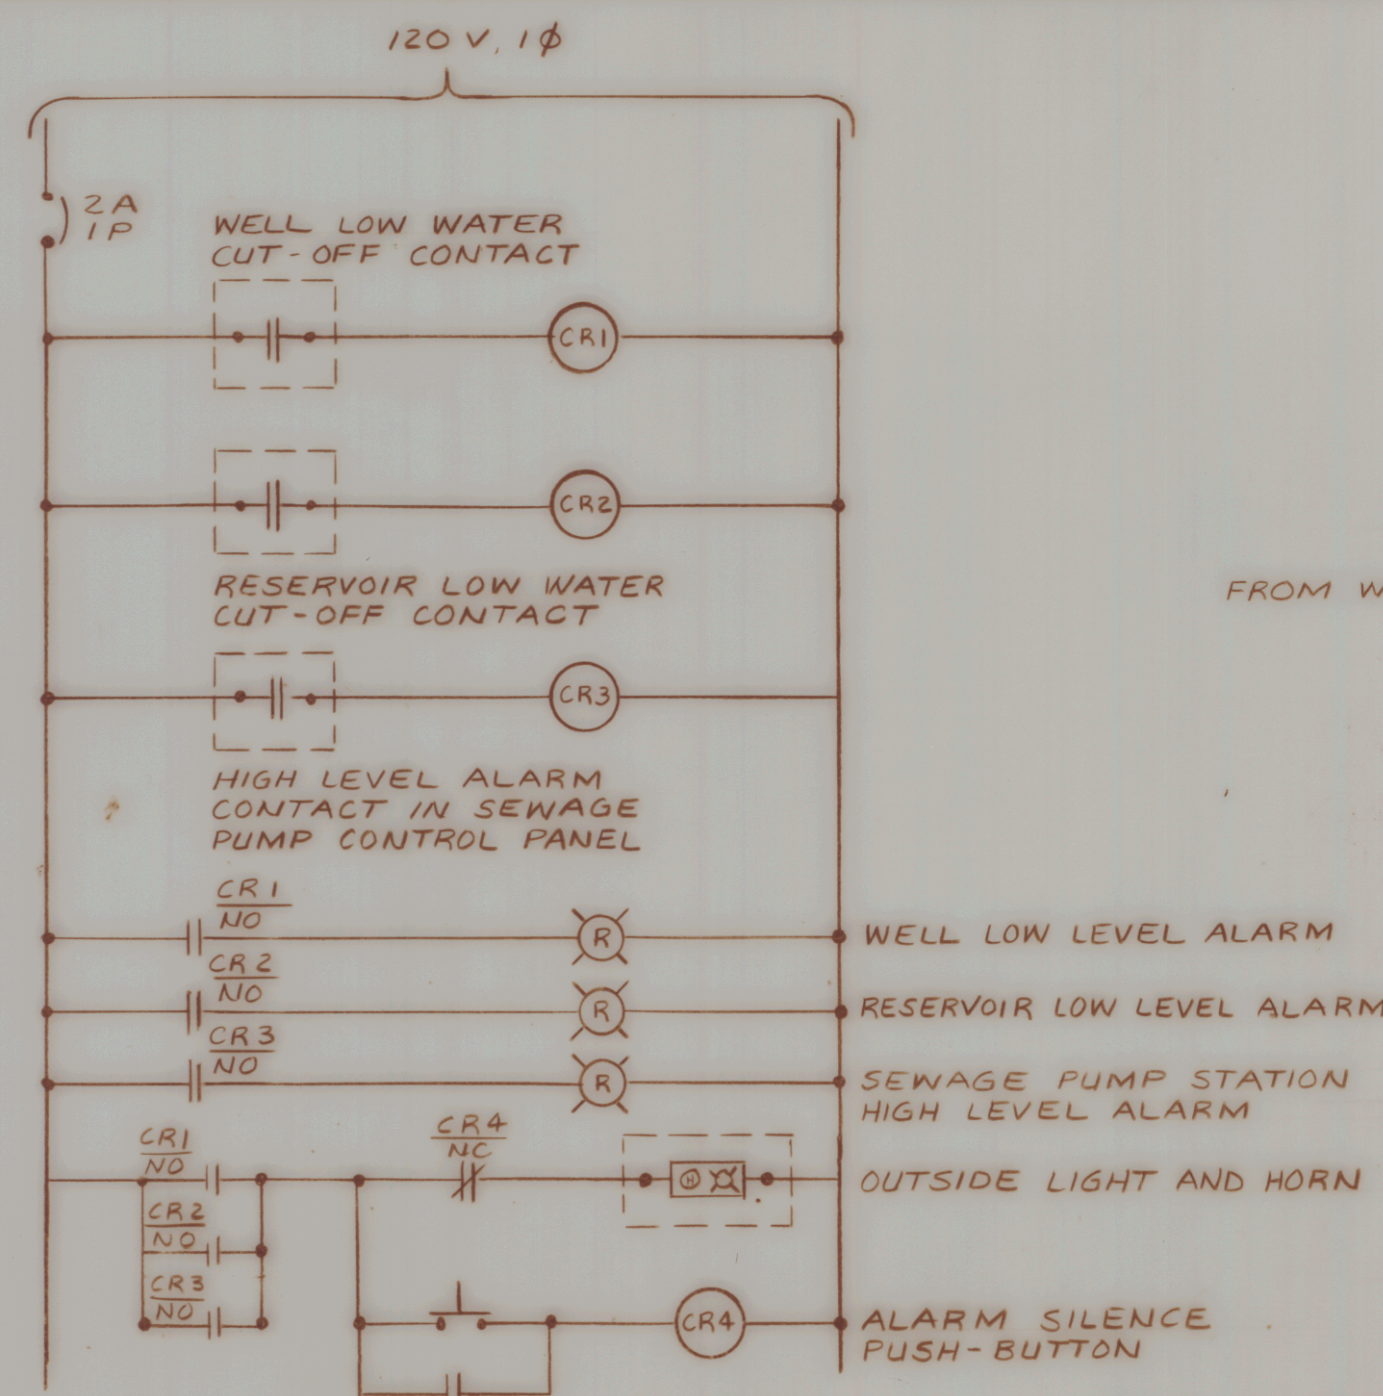


ALARM SCHEMATIC
NO SCALE

NOTE: ALARM SYSTEM FOR WATER & SEWAGE USE COMMON LIGHT AND HORN ON OUTSIDE OF BUILDING WITH INDIVIDUAL LIGHTS ON CONTROL PANEL.

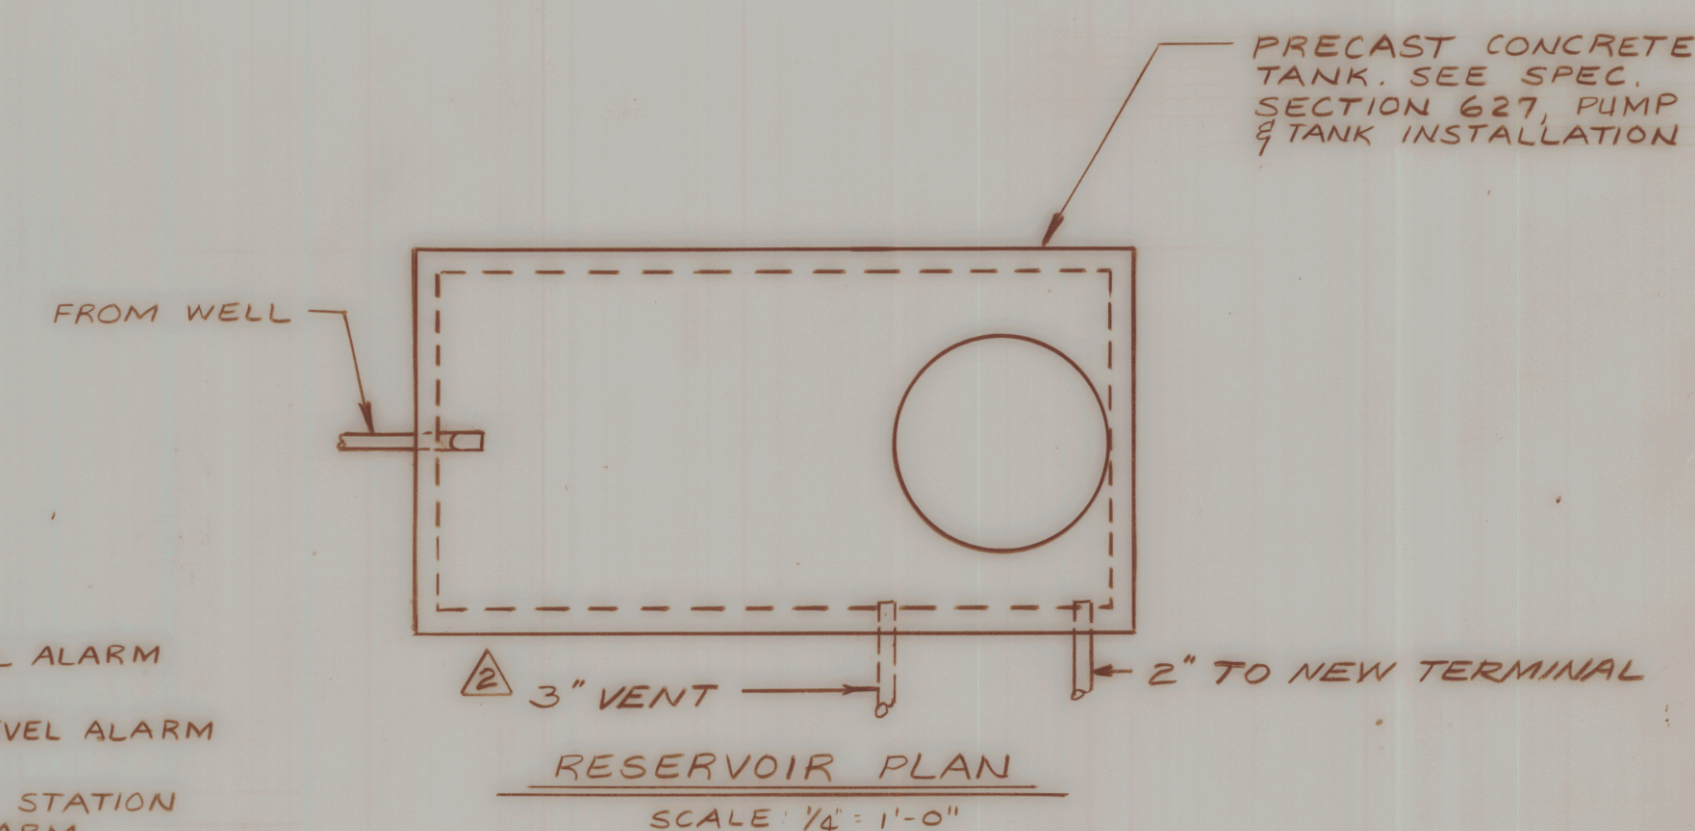


RESERVOIR PLAN
SCALE: 1/4" = 1'-0"

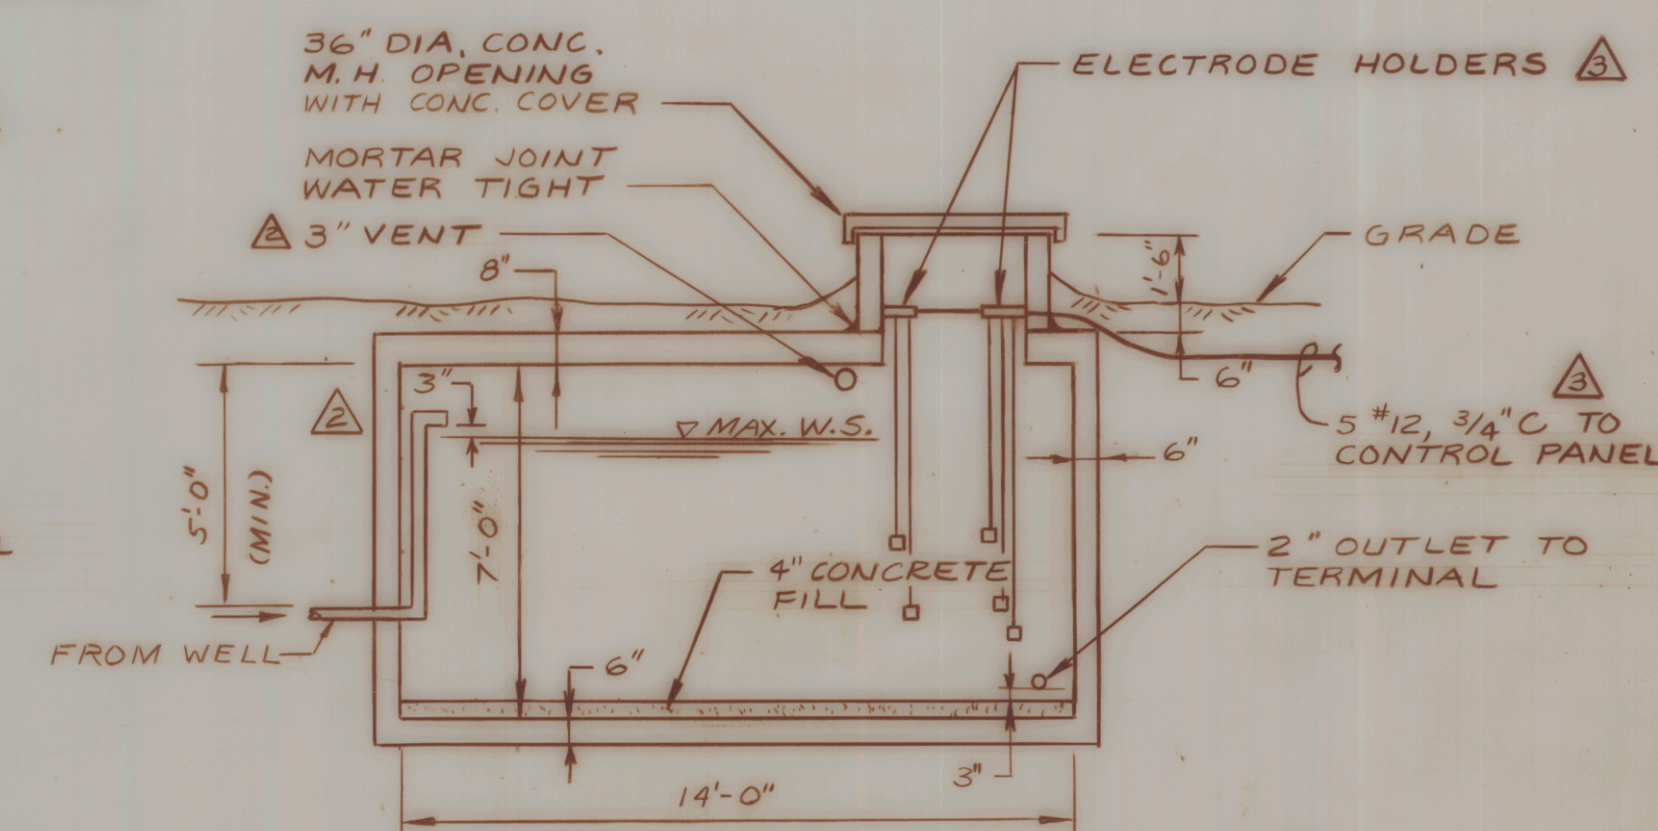

RESERVOIR SECTION
SCALE: 1/4" = 1'-0"

- NOTES:
1. PRECAST CONCRETE STRUCTURE TO BE MADE WATERTIGHT
 2. RESERVOIR SHALL BE PLACED ON A MINIMUM OF 1'-0" COMPACTED GRAVEL BASE WITH GRAVEL BACKFILL TO TOP OF STRUCTURE.

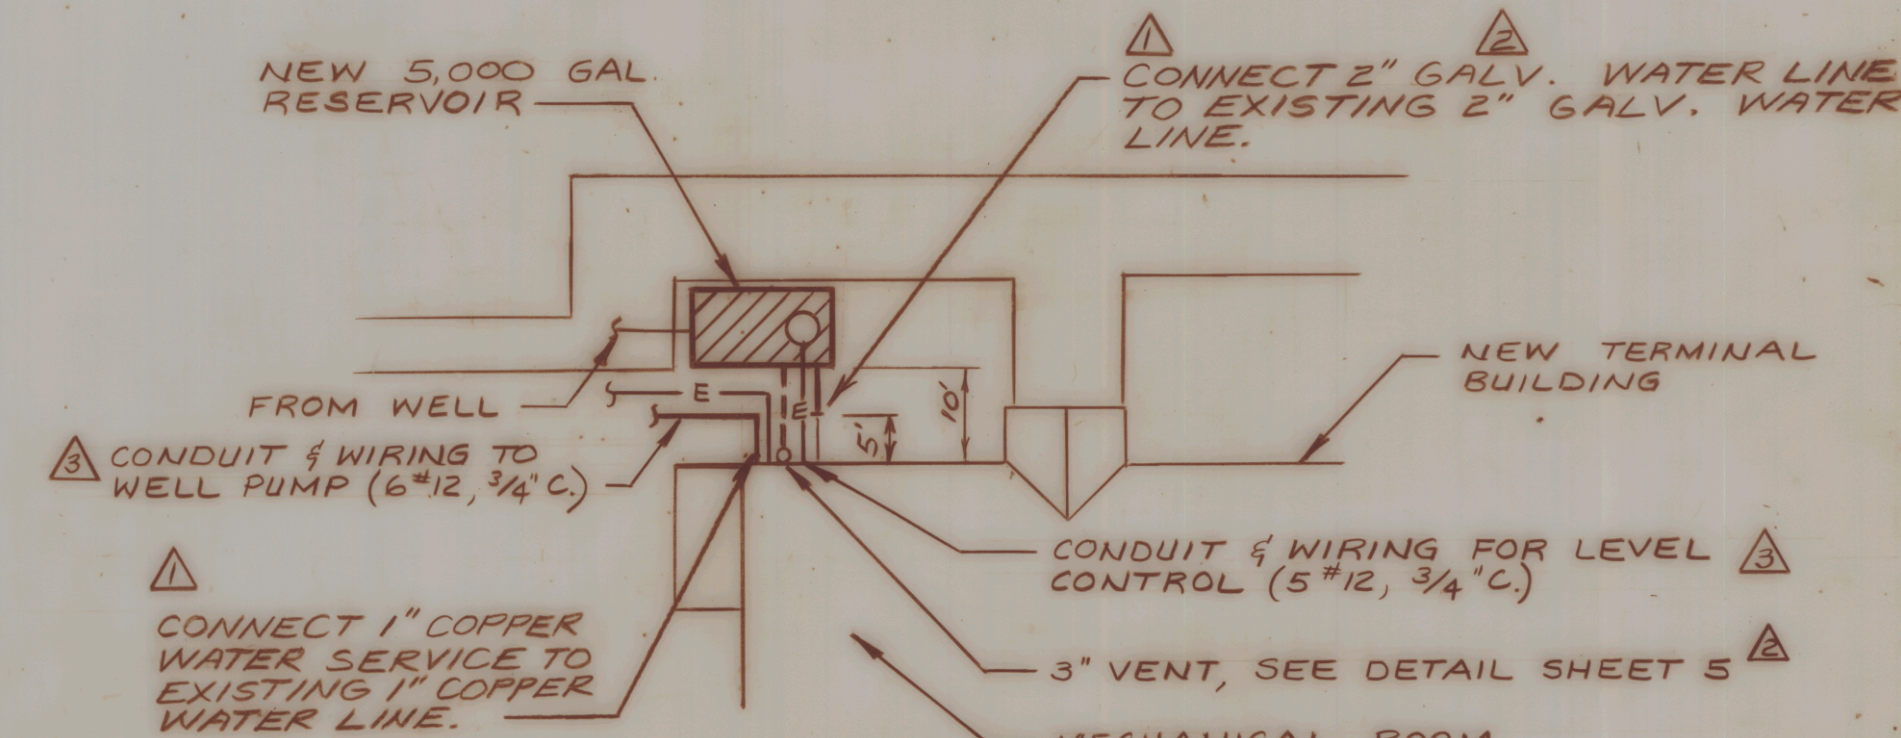

RESERVOIR LOCATION PLAN
SCALE: 1" = 20'

NOTE: ALL WATER PIPING FOR THE RESERVOIR, BOOSTER PUMP SYSTEM, AND THE PNEUMATIC TANKS SHALL BE GALVANIZED STEEL.

NO.	DATE	REVISIONS	BY	CHK'D
1	2/4/85	ADDENDUM NO. 1, MISC. ELEC. REV.	SJT	ESC
2	1/7/85	REV. PIPING, ADDED VENT & NOTES	ESC	ESC
3	10/3/84	REVISED WATER PIPING	ESC	ESC



DuBois & King Inc.
engineering planning management development

STATE OF VERMONT
AGENCY OF TRANSPORTATION
RUTLAND STATE AIRPORT
WATER SYSTEM
PLANS AND DETAILS
FACILITIES, POWER AND
CONTROL SCHEMATICS

ADDENDUM #1 Feb. 7, 1985	DRAWN BY SJT	DATE JULY 1984
CHECKED BY ESC	PROJ. NO. 45903	DRAW. NO. 5358
SHEET 6	OF 6	