



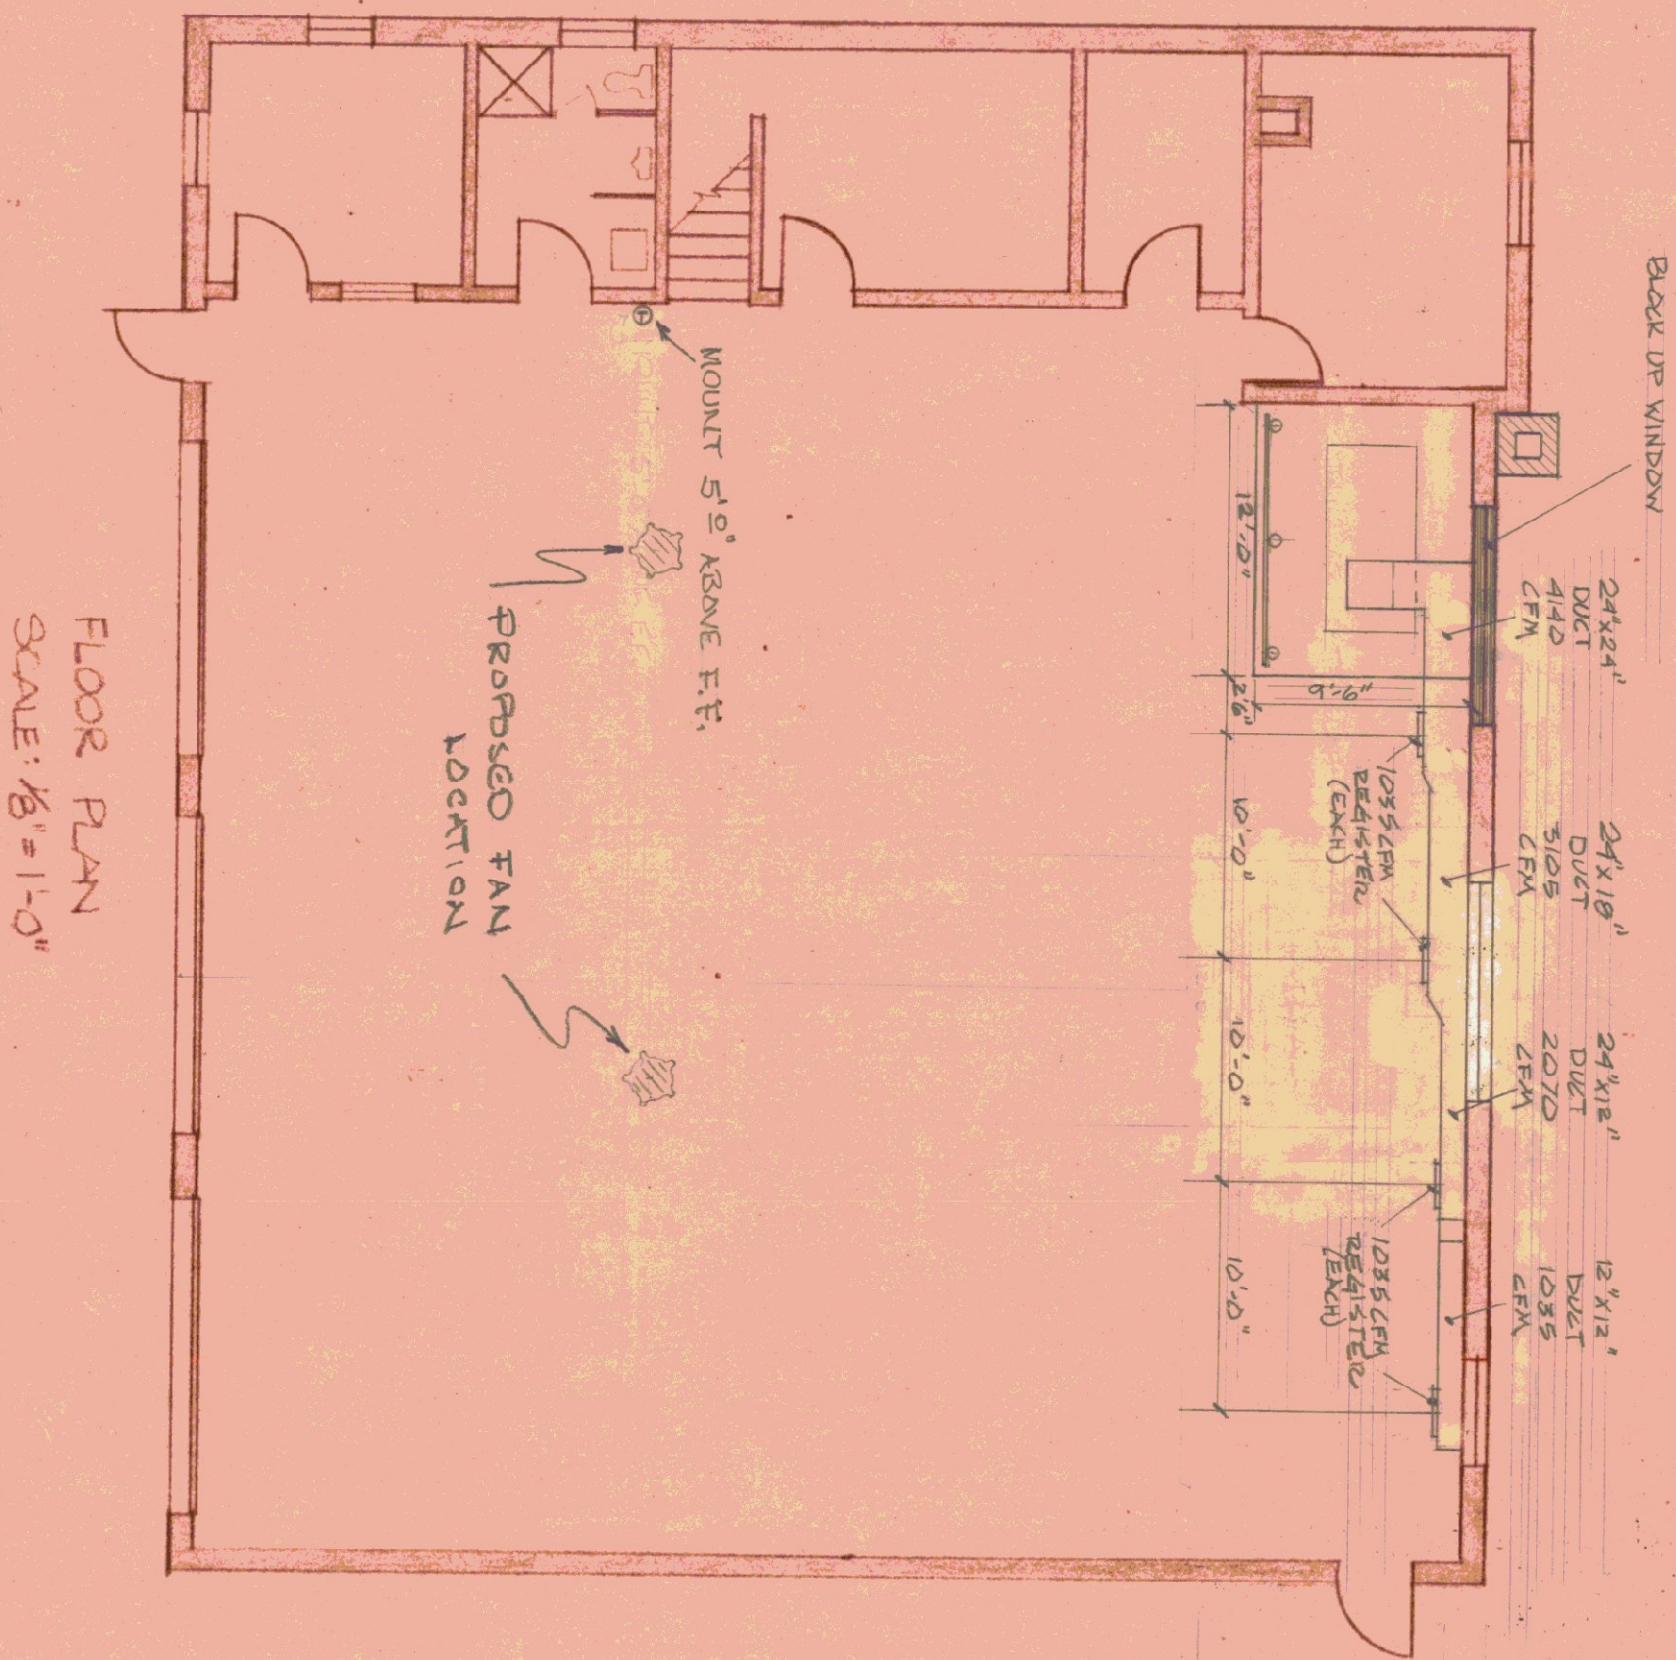

FLOOR PLAN
SCALE: 1/8" = 1'-0"

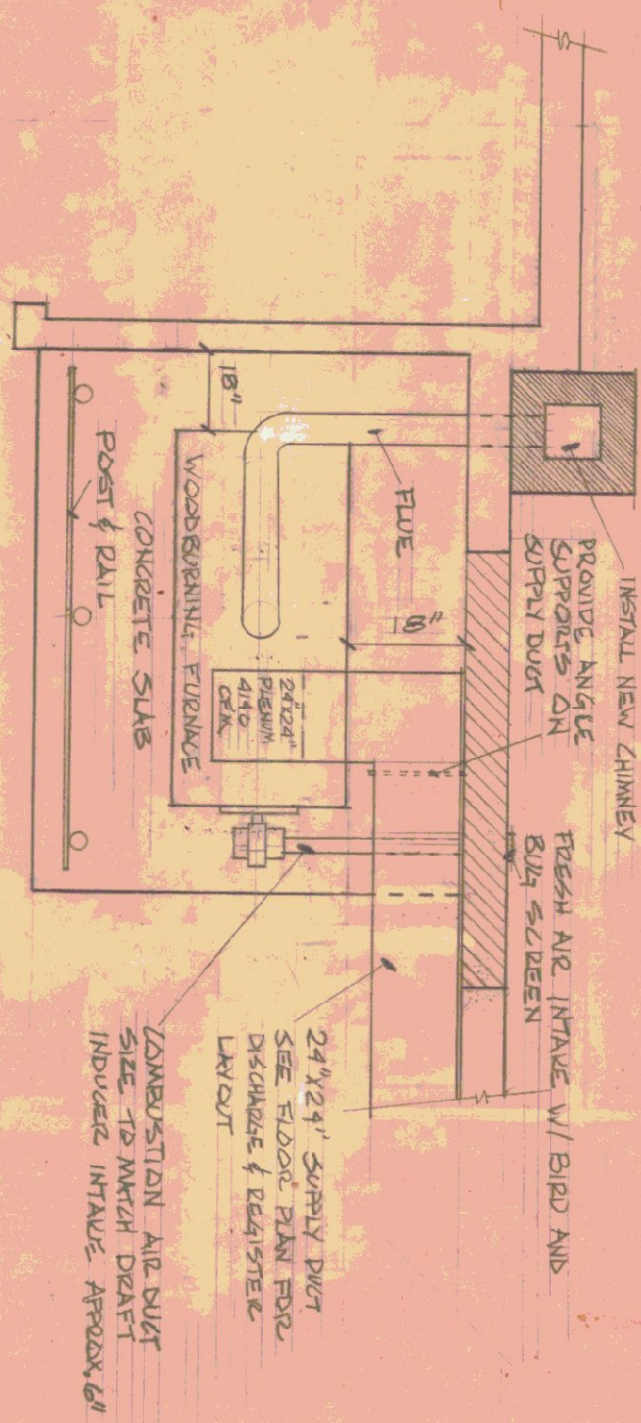

FURNACE SLAB 1/4" = 1'-0"

NOTE: FOR ADDITIONAL
DETAILS SEE SHEET 2.

STATE OF VERMONT
DIVISION OF STATE BUILDINGS
AGENCY OF ADMINISTRATION
MONTPELIER, VERMONT

WOODBURNING FURNACE INSTALLATION
© AGENCY OF TRANSPORTATION GARAGE
MILKINGTON, VERMONT

DATE: 7-21-80	SCALE: AS NOTED	REVISIONS: 10-17-80 RM	DWG. NO. 1 OF 3
DRAWN BY: JCF/RAH	APPROVED BY: JMM/RAH	10-23-80 RM	