



PUMPING SCHEDULE

P-1	AMERICAN STANDARD 18" HIGH EXHAUSTED CAPET TOILET MODEL 9408.018 SLOAN ROYAL FLUSH VALVE 110-3
P-2	AM. STD. WILKINE VALV. 20"X18" MODEL 0350.015" MODEL 2238.202. GOODENOCK SHUT
P-3	HALSEY TAYLOR BRACKET FTM. MODEL 6000

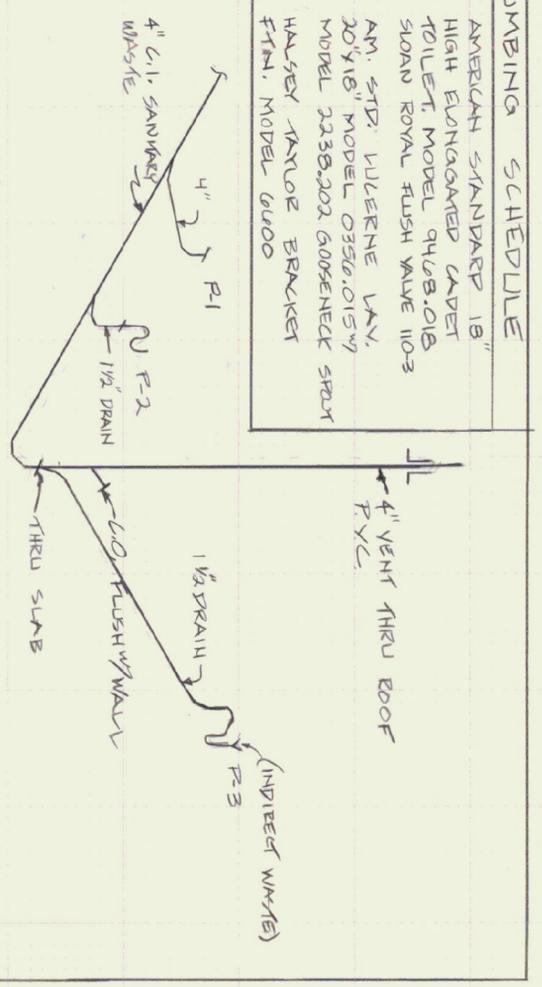

NOTE: ALL PIPE UNDER SLAB TO BE CAST SECOND

--- COLD WATER
--- HOT WATER

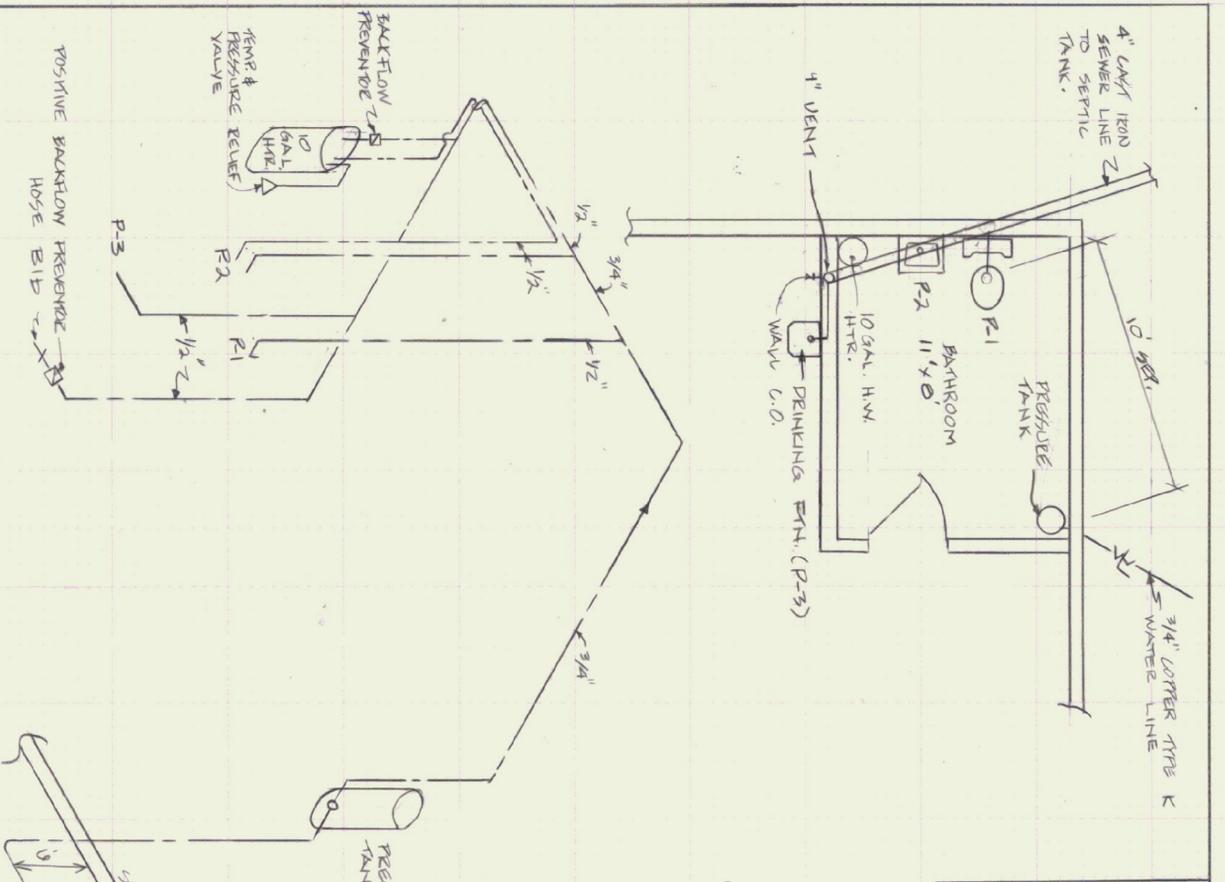

STATE OF VERMONT
DEPARTMENT OF STATE BUILDINGS
AGENCY OF ADMINISTRATION
MONTPELIER, VERMONT

TUNBRIDGE HIGHWAY GARAGE
PLUMBING DETAILS

TUNBRIDGE	SCALE: N.T.S.	REVISIONS:	VERMONT
DATE: 9/15/87	DRAWN BY: E. TERRELL	APPROVED BY: F. RAST	WG. NO. 2-1
			1 OF 1