



SITE PLAN
SCALE 1"=30'

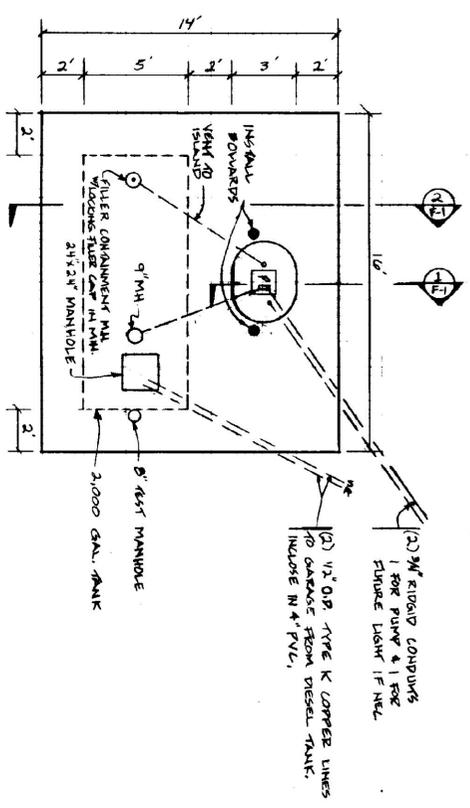


SLAB PLAN
SCALE 3/4"=1'-0"

(1) 3/4" RIGID CONDUITS
1 FOR PUMP & 1 FOR
SHURE LIGHT IF NEEDED


(2) 1 1/2" O.D. TYPE K COPPER LINES
TO GARAGE FROM DIESEL TANK.
INCLUDE IN 4" FILL.

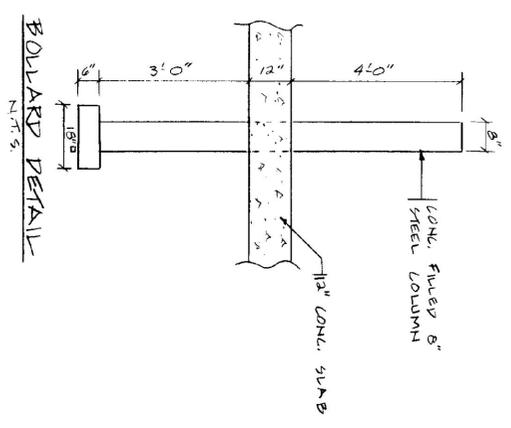

BOLLARD DETAIL
N.T.S.

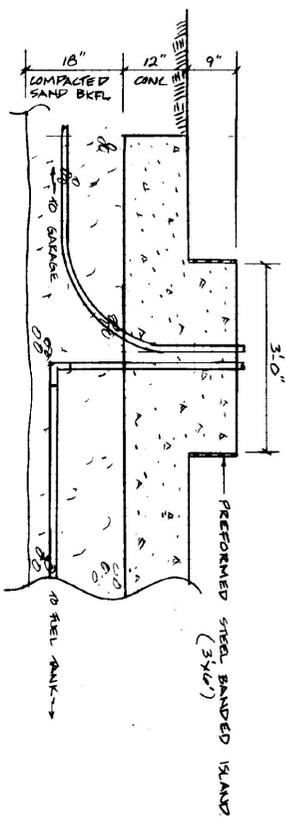

SECTION 1
SCALE 3/4"=1'-0"

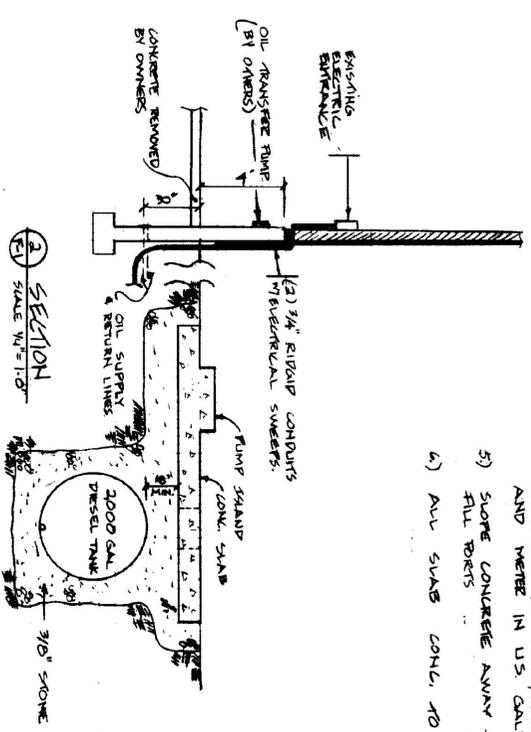

SECTION 2
SCALE 3/4"=1'-0"

- NOTES**
- (3000 GALL.) DIESEL TANK TO BE STI-PS SYSTEM W/ DOUBLE WALL. TGA, INHERENTLY, 100% UNDERWALL.
 - CONTAINMENT MANHOLE IS TO HAVE A WATER TIGHT SEAL. ALSO DELETE DRAIN RETURN TUBE & DRAIN VALVE.
 - ALL INSTALLATIONS ARE TO CONFORM TO STATE OF VERMONT, UNDERGROUND STORAGE TANK REGULATIONS, DATED MARCH 1, 1987.
 - PROVIDE GAS BOY MODEL 53 PR PUMP. W/ DIESEL FILTER, 1 1/2" CHECK VALVE, STANDARD 12" HOSE, AUTOMATIC NOZZLE, AND WETTER IN US GALLONS.
 - SLOPE CONCRETE AWAY FROM ALL MATH & FILL BERTS
 - ALL SLABS CONCL. TO BE CLASS B.

STATE OF VERMONT DEPARTMENT OF STATE BUILDINGS AGENCY OF ADMINISTRATION VERMONT MONTPELIER.			
FILED ISLAND SLAB & TANK DETAIL PLAN FOR KUNBRIDGE A.O.T. GARAGE			
DATE 2/8/88	SCALE AS SHOWN	REVISIONS	VERMONT DWG NO 1
DRAWN BY E. REBEAU	APPROVED BY E. REBEAU		1 OF 1