


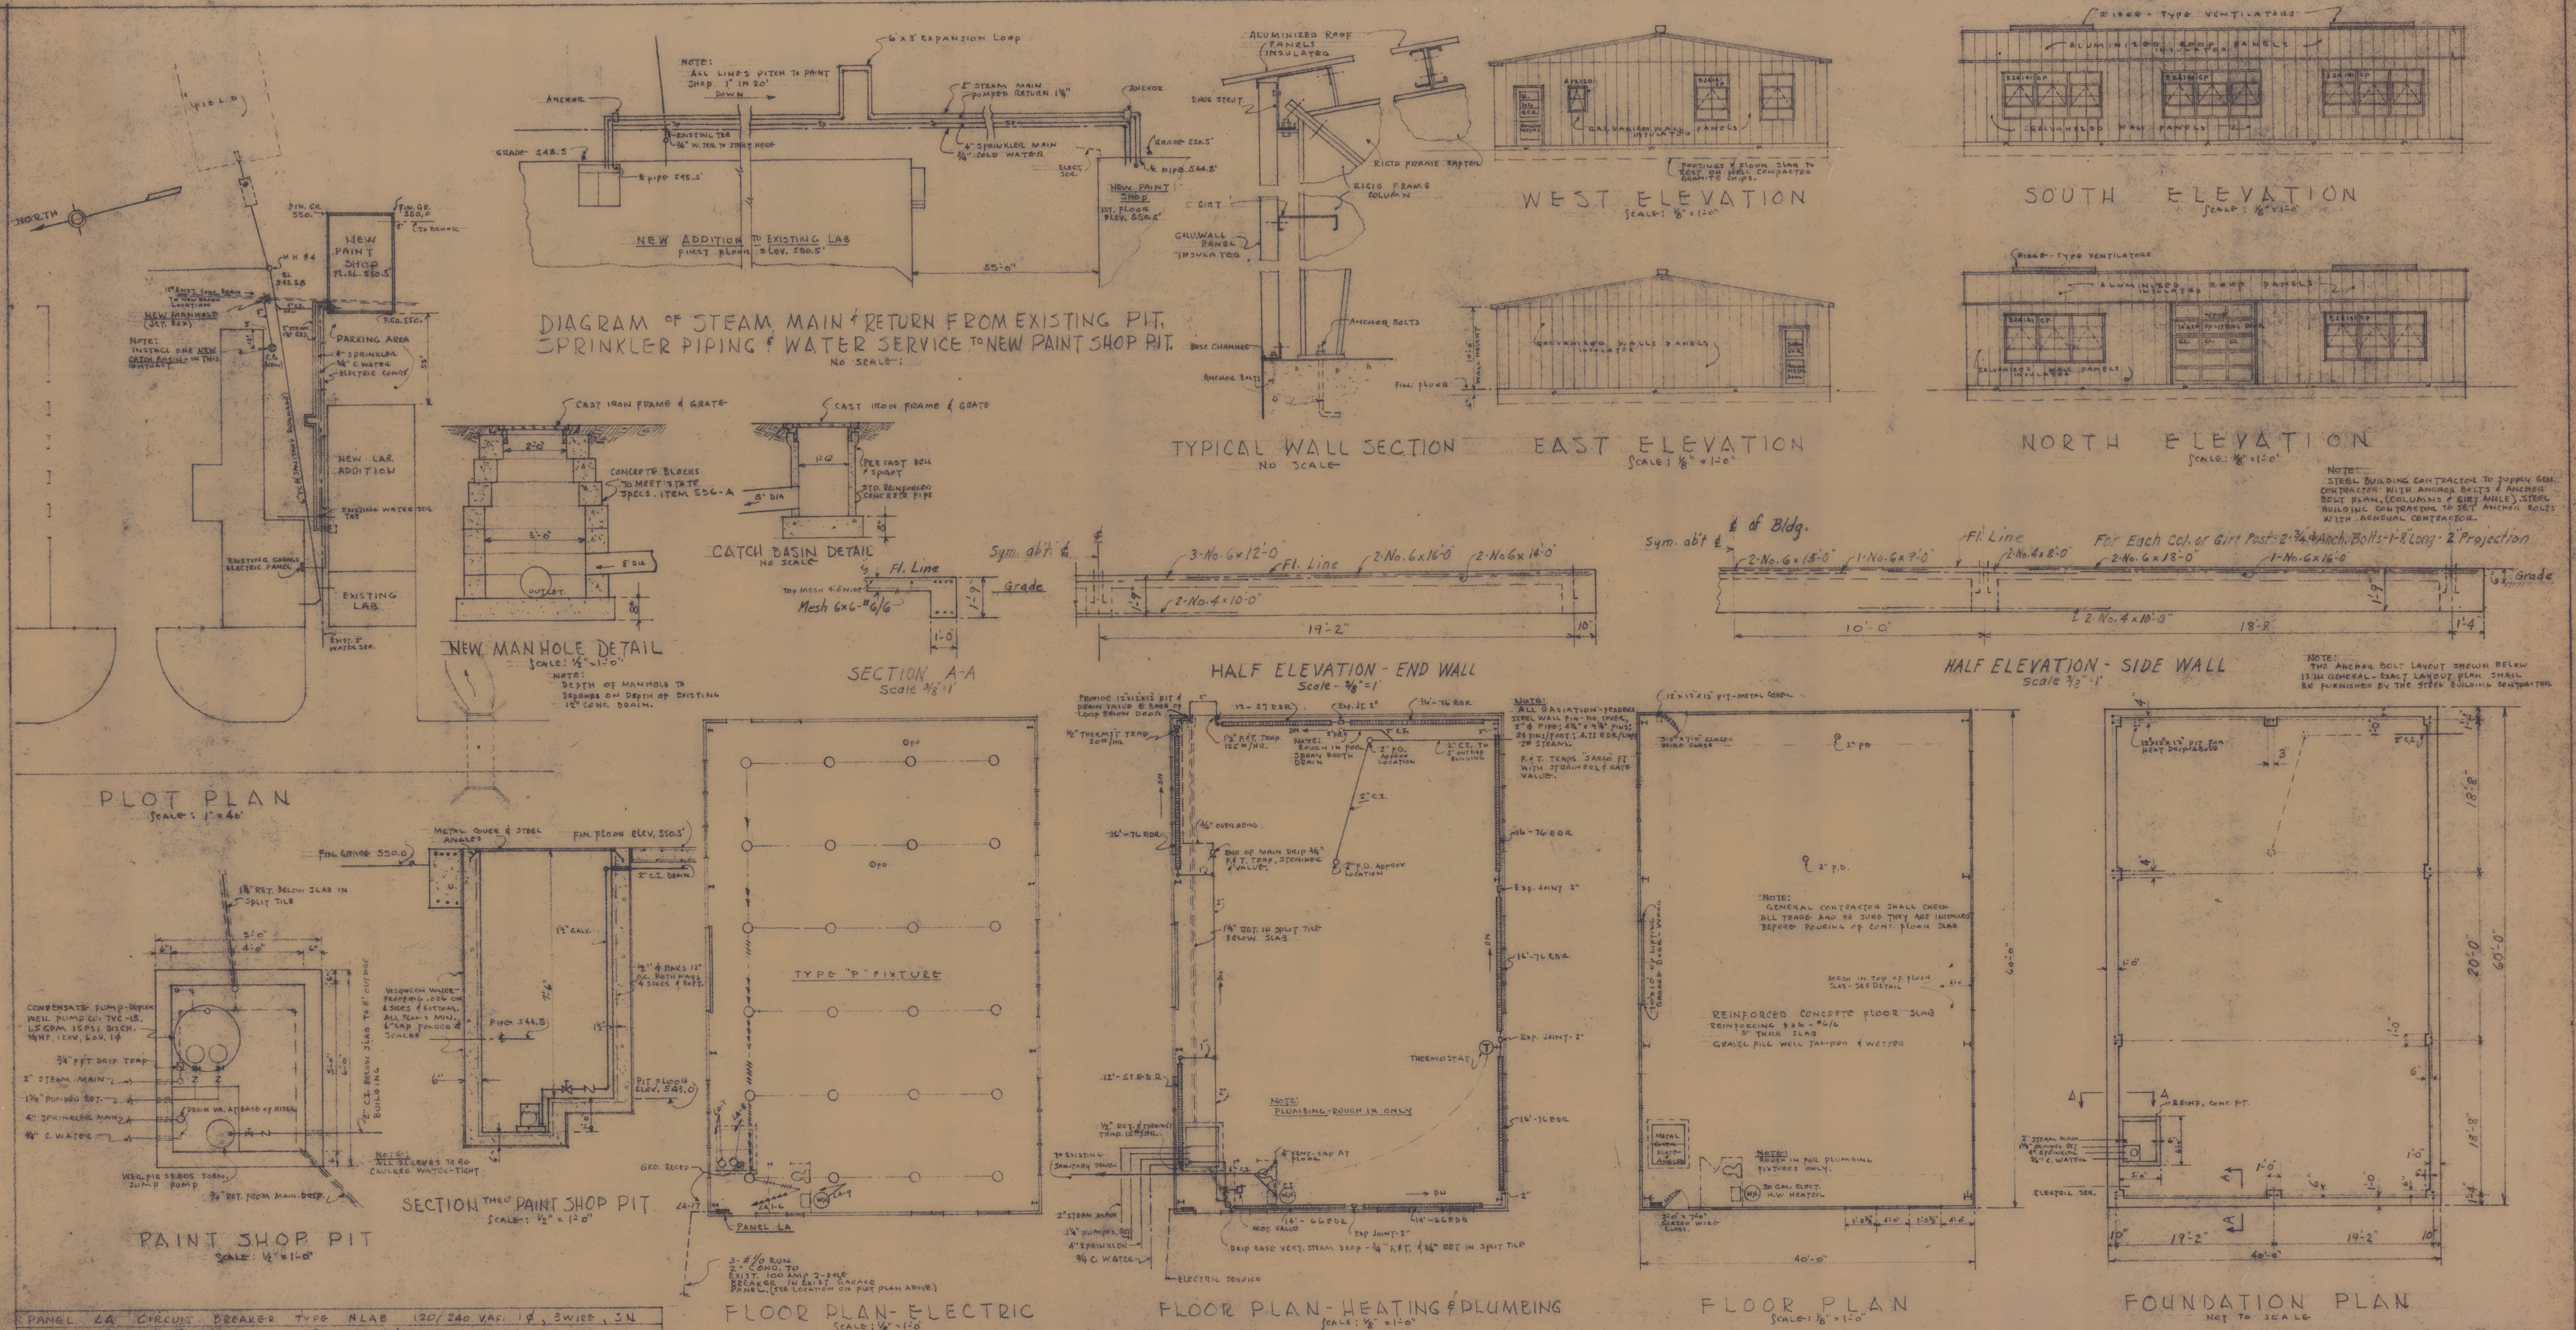

PANEL LA CIRCUIT BREAKER TYPE NLAB 120/240 VAC. 1Ø, 3WIRE, 3N				
100 AMP. MAIN BREAKER				
BRANCH CIRCUIT				
NO.	BREAKER	POLES	AMPS	WIRING
1-6	1	20	1	7.2
7	1	20	1	1/4"
8	1	20	1	1/4"
9	2	20	1	1/2"
10-14	1	20	1	1/2"
15-16	2	20	1	1/2"
17	1	20	1	1/2"
EQUIPMENT				
PAINT SHOP				
FIXTURES				
COND. PUMP				
WATER HEATER				
SPARKS				
PUMP PUMP				


FLOOR PLAN - ELECTRIC
Scale: 1/8" = 1'-0"

FIXTURE SCHEDULE:
TYPE "P" HOLOPHANE NO. 684, LOWBAY REFLECTOR 300W. I.F. LAMP, PENDANT MOUNT 11'-0" ABOVE FIN. FLOOR.

FLOOR PLAN - HEATING & PLUMBING
Scale: 1/8" = 1'-0"

FLOOR PLAN
Scale: 1/8" = 1'-0"

FOUNDATION PLAN
Not to Scale

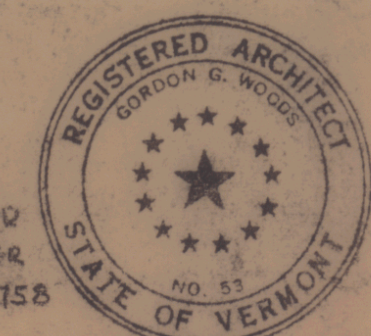

MERTON B. BADGER
CONSULTING ENGINEER
VT. REG. LICENSE NO. 758

NEW PAINT SHOP FOR
STATE HIGHWAY DEPT.
MONTPELIER, VERMONT

GORDON G. WOODS
ARCHITECTS & ENGINEERS
ST. JOHNSBURY, VERMONT

DATE: APR. 61
SHEET: 602
1PS