




FLOOR PLAN
SCALE: 1/8" = 1'-0"

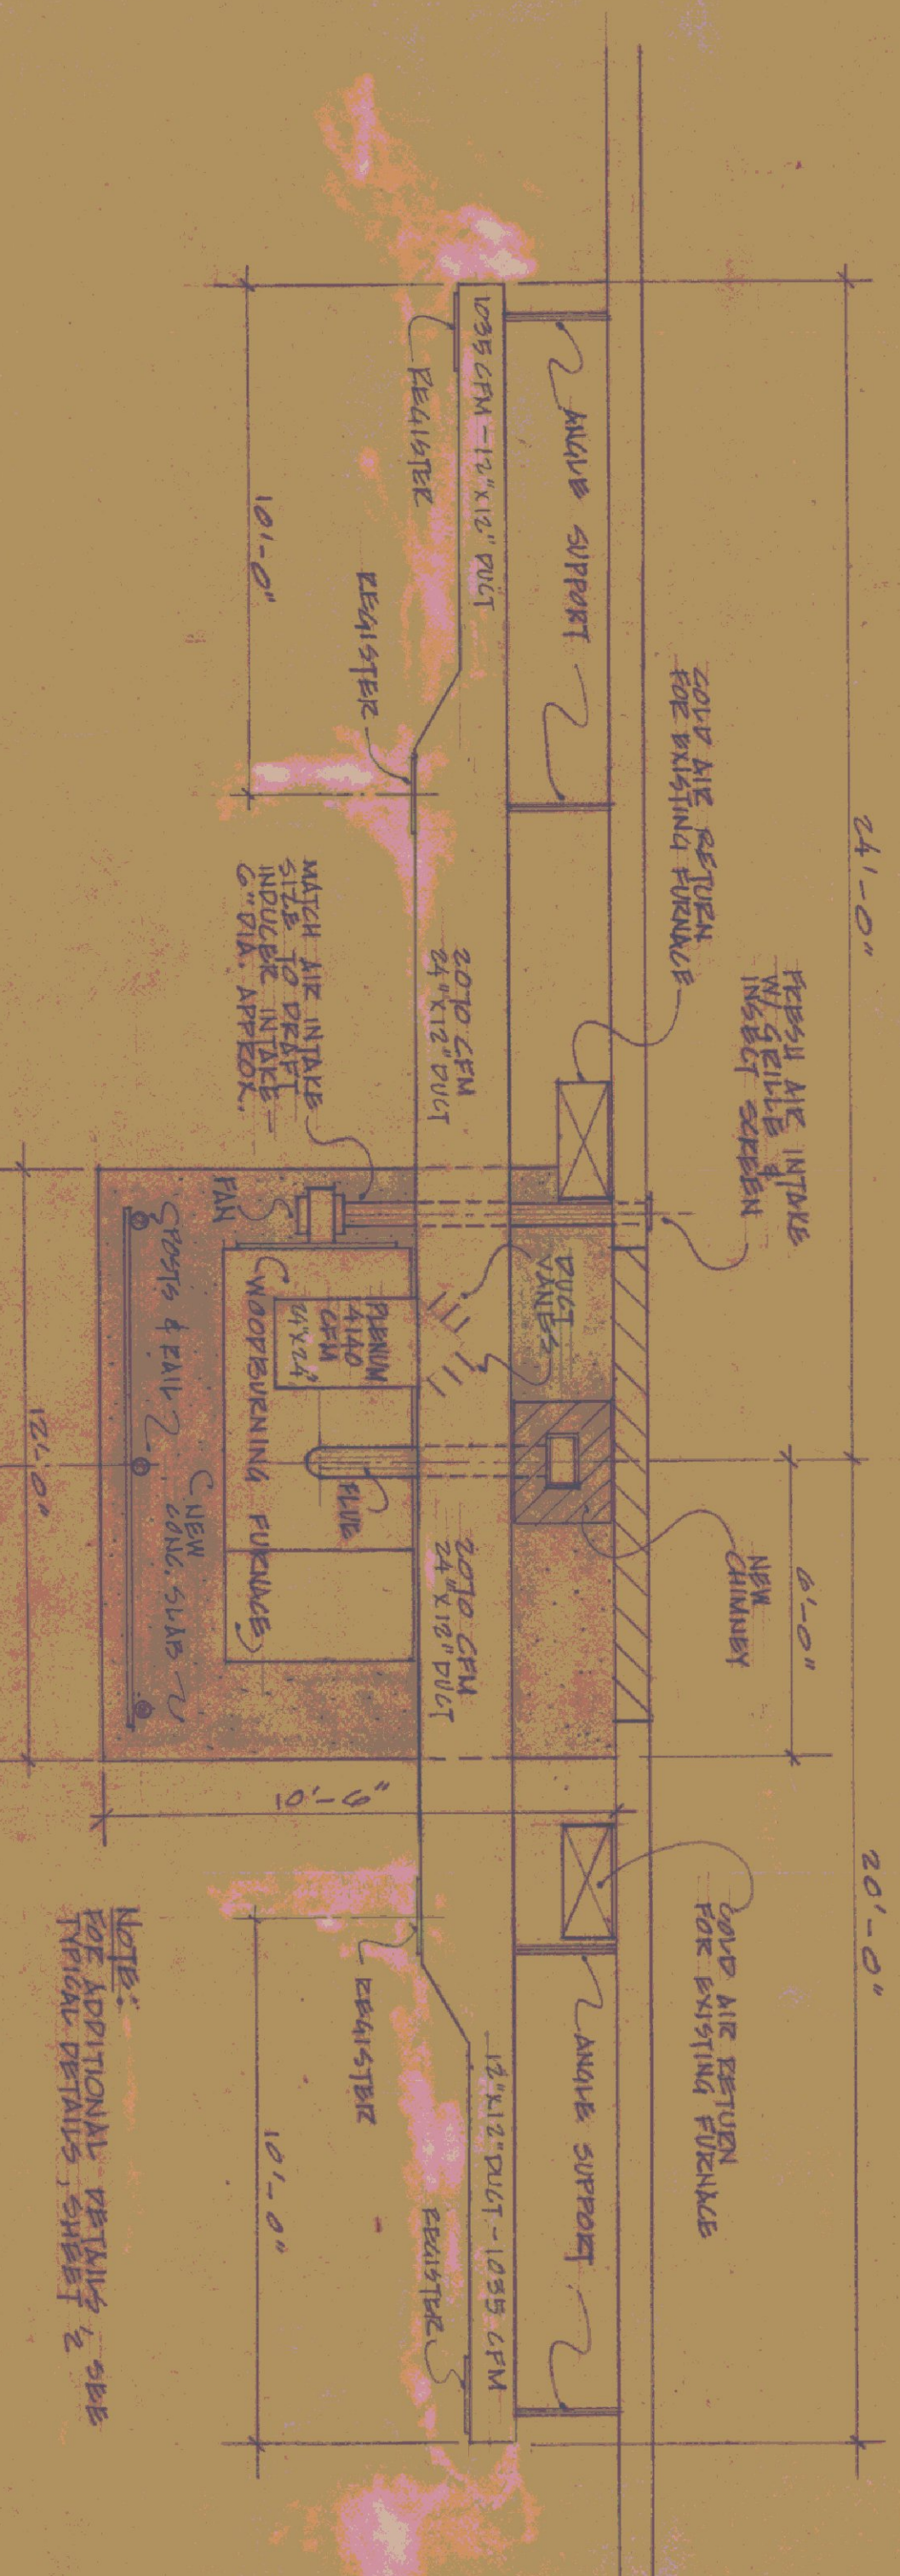

NOTE:
FOR ADDITIONAL DETAILS, SEE
TYPICAL DETAILS, SHEET 2

PLAN @ FURNACE SLAB
1/4" = 1'-0"

STATE OF VERMONT			
DIVISION OF STATE BUILDINGS			
AGENCY OF ADMINISTRATION			
MONTPELIER, VERMONT			
WOODBURNING FURNACE INSTALLATION @			
AGENCY OF TRANSPORTATION AGENCY			
BARTON, VT.			
DATE: 7-28-80	SCALE: AS NOTED	REVISIONS: CHANGES 10-15-80	DWG. NO. 1 OF 3
DRAWN BY: J. J. J. J.	APPROVED BY: J. J. J. J.		