



FLOOR PLAN  
SCALE: 1/8" = 1'-0"

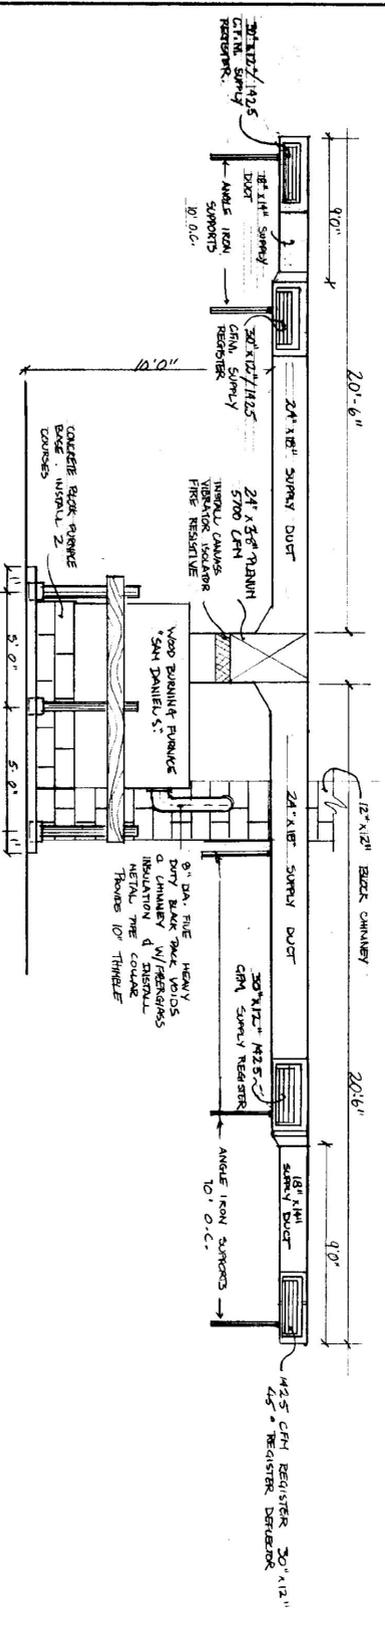

ELEVATION OF FRONT OF FURNACE  
SCALE: 1/4" = 1'-0"

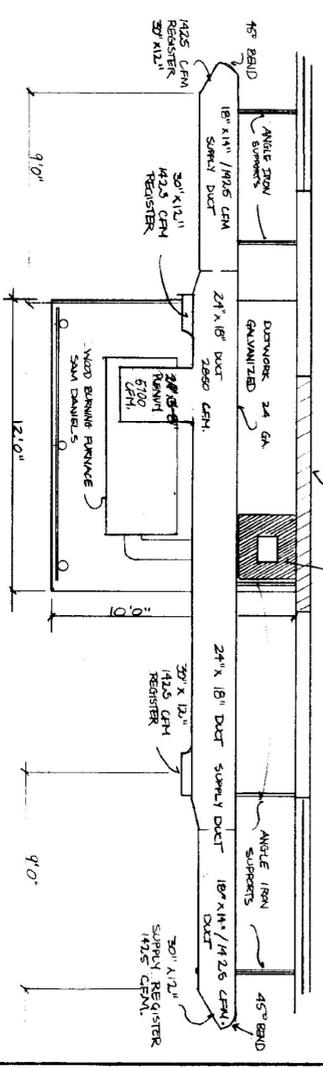

PLAN OF FURNACE & SLAB  
SCALE: 1/4" = 1'-0"

- NOTE:
- SUPPLY REGISTERS ARE ADJUSTABLE DOUBLE DEFLECTOR W/ VOLUME DAMPER, ALUMINUM - CABINET MODEL 6521 OR EQUIV. THOUGH ALUMINUM ARMED BLADE VOLUME-DAMPER BEHIND EACH REGISTER.
  - PROVIDE SHIP BUNKER BENDS IN ALL DUCT-WORK.
  - PROVIDE FILTERS IN ALL RETURN AIR DUCTS.

STATE OF VERMONT			
DIVISION OF STATE BUILDINGS			
AGENCY OF ADMINISTRATION			
VERMONT			
WOOD BURNING FURNACE INSTALLATION			
AT THE AGENCY OF TRANSPORTATION GARAGE			
WESTFIELD VERMONT			
DATE:	SCALE:	REVISIONS:	DWG. NO.:
10/5/89	AS NOTED		
DRAWN BY:	APPROVED BY:		
Louiseley			
			OF