


TYPE	MANUFACTURER	CAT. No.	LAMPS	DIFFUSER	MOUNTING	REMARKS	ALTERNATE MFR'S.
A	KESTONE	2J 440 EDA 120 LE	(4) F40/CW/RS/ES	AEROLIC	RECESSED GRID	EMERGENCY BALLAST	DAYBRITE, KEENE, METALUX
AI	KESTONE	2J 440 EDA 120 LE EL	(4) F40/CW/RS/ES	AEROLIC	RECESSED GRID	EMERGENCY BALLAST	
B	KESTONE	2SM 340 EDA 120 WR LE	(3) F40/CW/RS/ES	AEROLIC	SURFACE	EMERGENCY BALLAST	
B	KESTONE	2SM 340 EDA 120 WR LE EL	(3) F40/CW/RS/ES	AEROLIC	SURFACE	EMERGENCY BALLAST	
C	KESTONE	1U 240 EDA 120 LE	(2) F40L/CW/RS	AEROLIC	RECESSED GRID		
D	KESTONE	2PRN 440 A 120 LE	(2) F40/CW/RS/ES	AEROLIC	SURFACE		
D	KESTONE	2PRN 440 A 120 LE EL	(2) F40/CW/RS/ES	AEROLIC	SURFACE	EMERGENCY BALLAST	
E	RUDO	E440-0-85-ESB-7-120V	(1) 70 W M.H.	DEEP SHIELDED	WALL OVER DOOR	INTERNAL PHOTOCELL	
F	KESTONE	20M 440 A 120 LE	(4) F40/CW/RS/ES	AEROLIC WRAP	SURFACE		
G	KESTONE	SAME AS TYPE 'A' EXCEPT WITH ADDITIONAL LENS GRINDING	(4) F40/CW/RS/ES	AEROLIC WRAP	SURFACE		
X	PRESCOTT	EX-R-EMF-A-120V	(2) 15W T8	SINGLE FACE	UNIVERSAL	EMERG. EXIT LIGHT	
XI	PRESCOTT	EX-R-EMF-A-120V	(2) 15W T8	DOUBLE FACE	UNIVERSAL	EMERG. EXIT LIGHT	

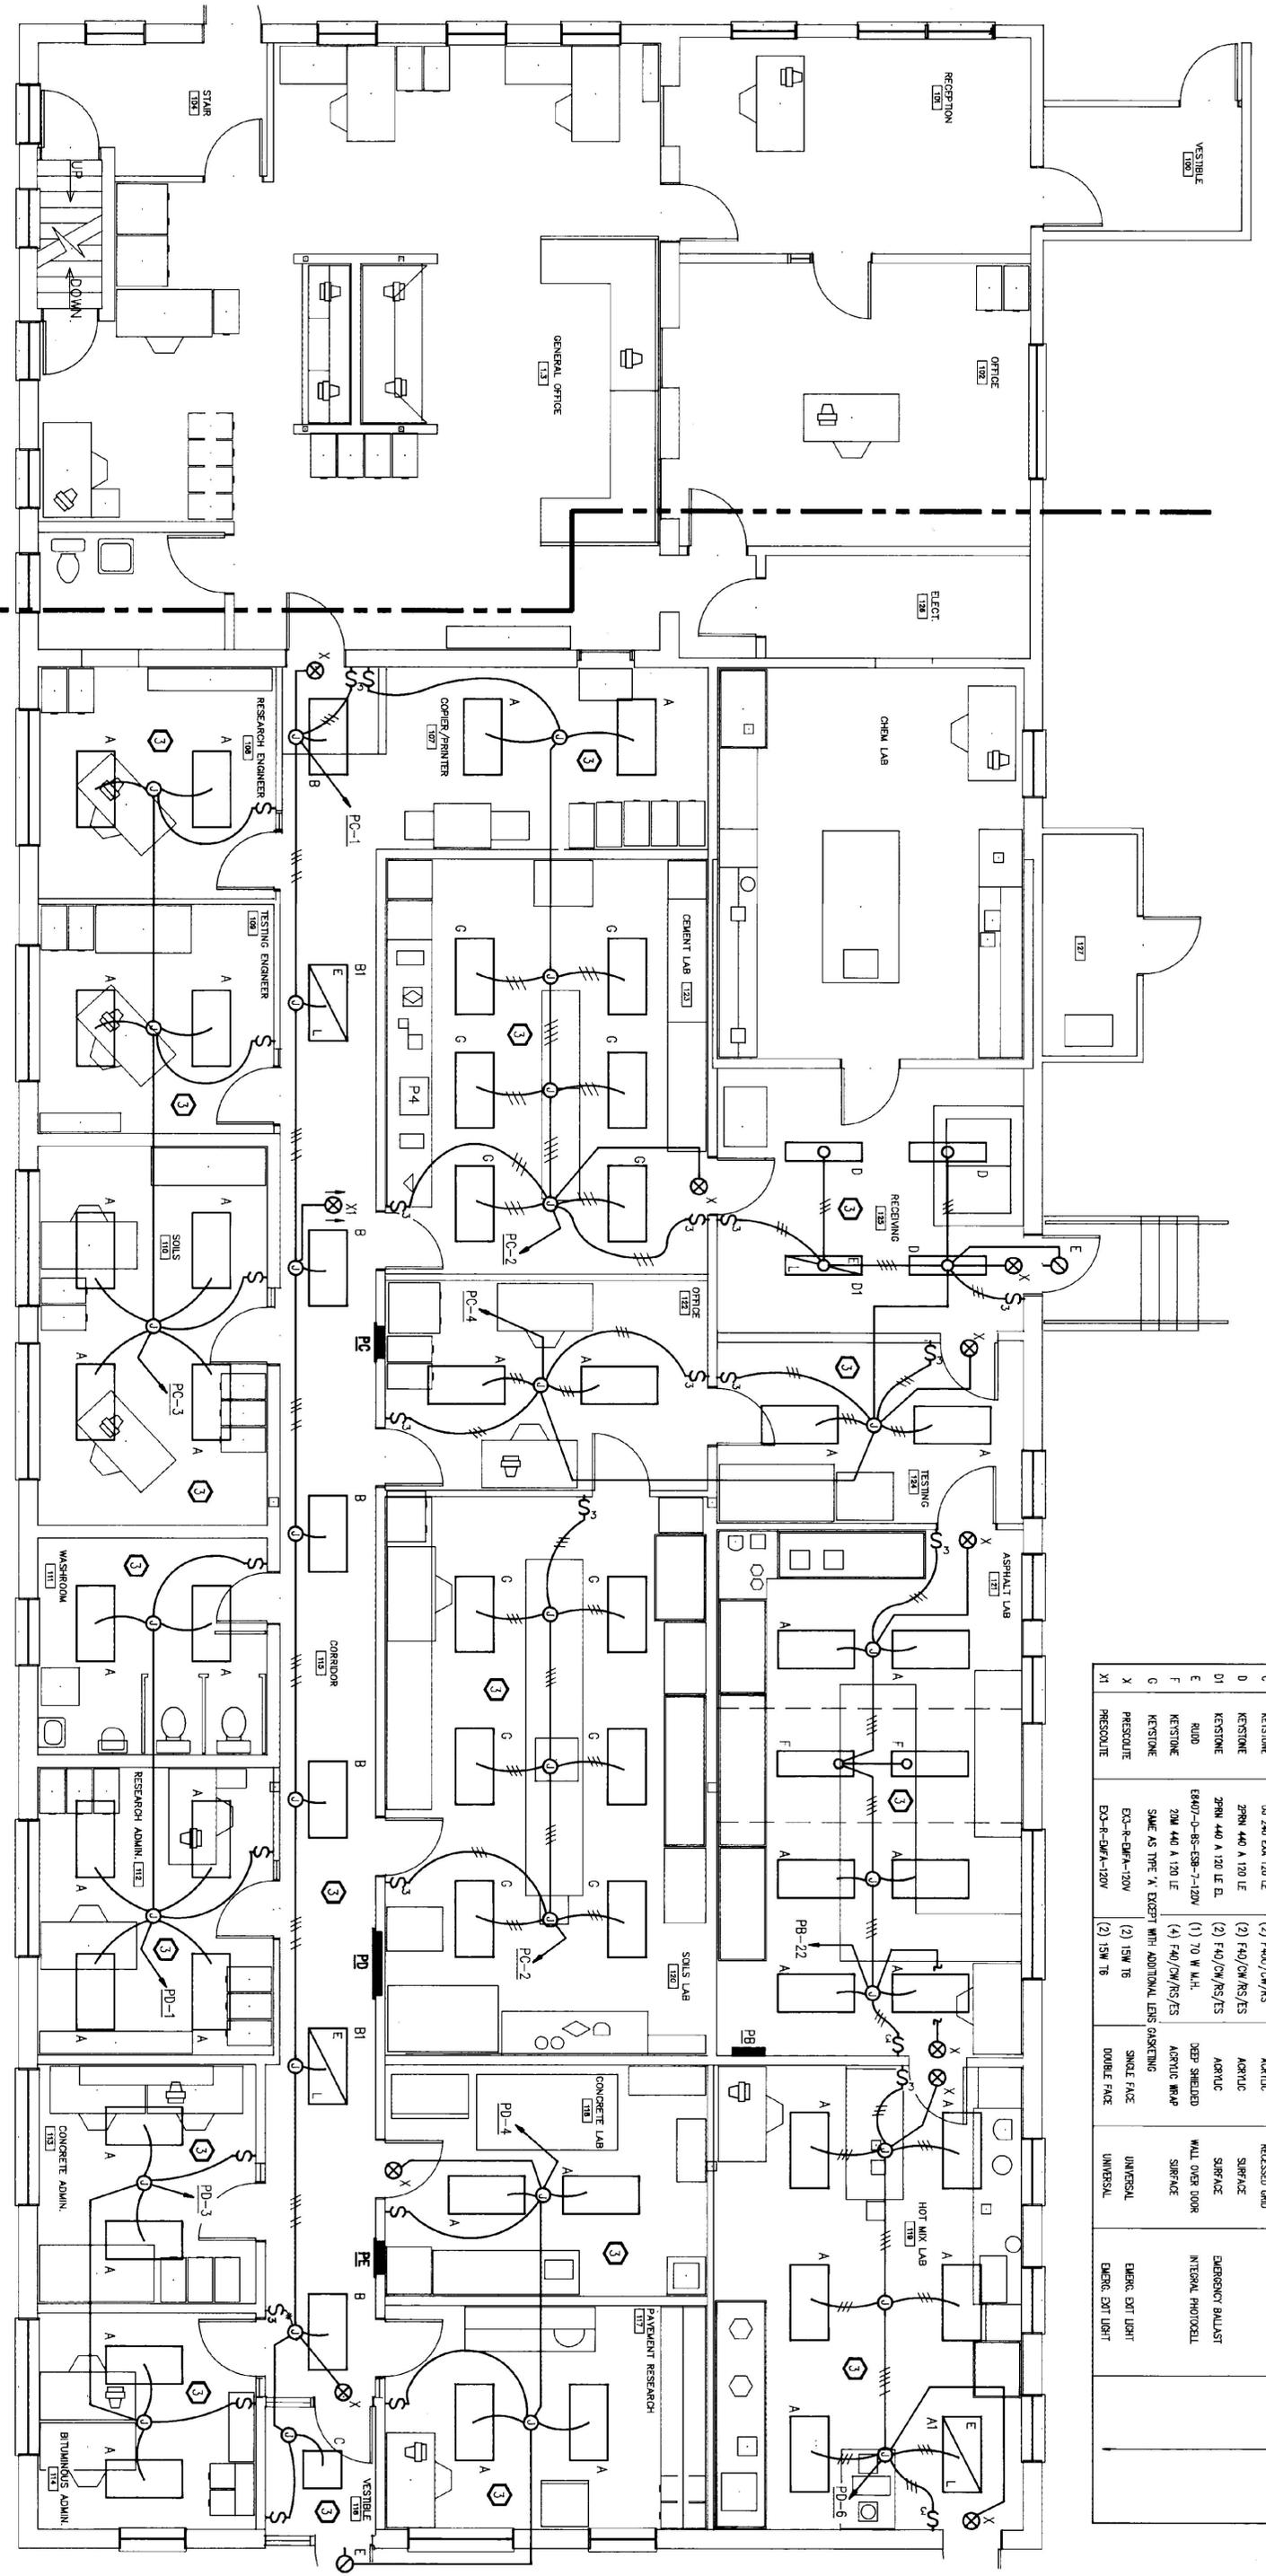

PHASE III CONTRACT LIMIT
LIGHTING PLAN
1/4" = 1'-0"



Tolbach Engineering, Inc.
Consulting Engineers
20 Kindel Ave. Suite 102, S. Burlington, VT 05403
(802) 888-4044

State of Vermont
Department of State Buildings
John Zampieri, Commissioner

Materials & Research
Laboratory
Berlin, Vt.
PHASE III

Janson Design, Inc.
FRED KEL, ARCHITECT
P.O. BOX 55 - BOSTON ROAD, WATERBURY, VT 05678
(802) 244-5800

PHASE III FLOOR PLAN
FIRST FLOOR
STATE HIGHWAY LAB
DATE: 1-10-91
DWG. NO. E-6