


DEMOLITION NOTES:

- D1 Remove all existing ductwork connected to existing MTA unit "A".
- D2 Remove all pneumatic controls and motor in existing MTA unit "A" in preparation for new electronic controls.

NEW MECHANICAL WORK NOTES:

- 1 Existing Make-Up-Air Unit: Modify ductwork and controls as shown on drawings and detail in specifications. Replace all pneumatic controls with electronic. Replace motor with three-speed, two-winding motor.
- 2 New Make-Up-Air Supply ductwork. Run tight to roof joists except where noted to be in joist space to get above existing air conditioning ductwork.

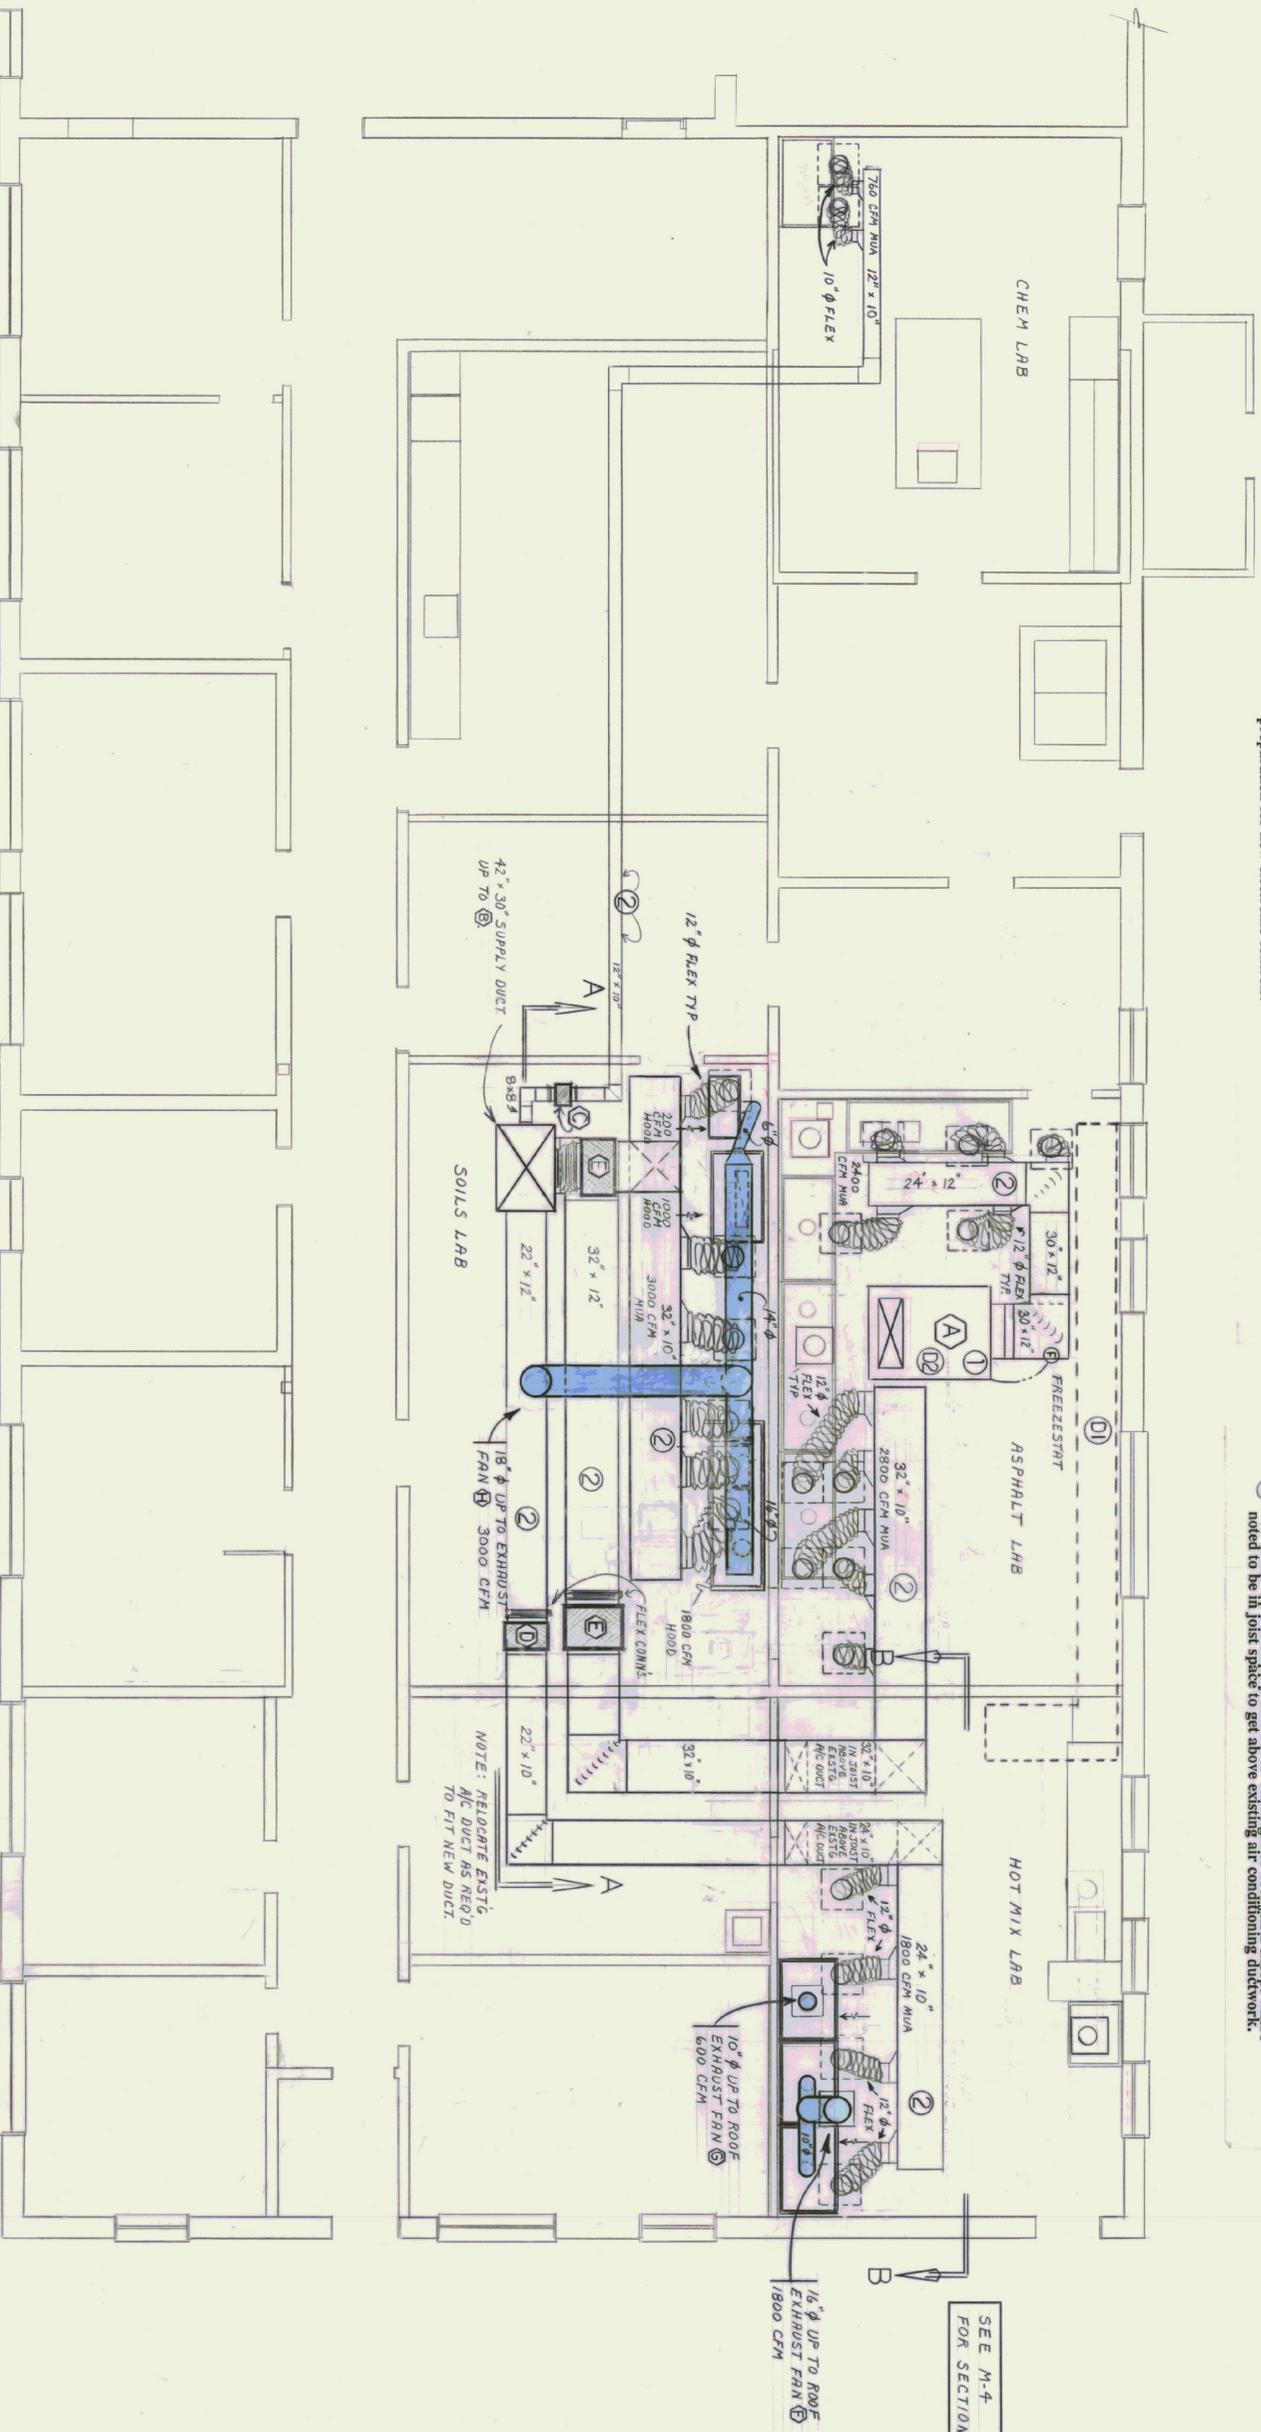

EAST END FIRST FLOOR PLAN

Scale: 1/4" = 1'-0"

MECHANICAL CONSULTANT:

GWR Engineering, P.C.
 P.O. Box 157 - The Community Building
 Shelburne, VT 05482
 Tel: (802) 965-8061 FAX: (802) 965-5499



Materials & Research
 Laboratory
 Berlin, Vt.

State of Vermont
 Department of State Buildings
 John Zampieri, Commissioner

PHASE III

ARCHITECT:

Janson Design, Inc.
 FRED XEL ARCHITECT
 P.O. Box 55 - Bolton Road, Waterbury, VT 05676
 (802) 244-5800

PHASE III FLOOR PLAN
 FIRST FLOOR
 MECHANICAL
 VENTILATION PLAN

1-10-91

M-9

1 OF 3

SEE M-4
 FOR SECTIONS