

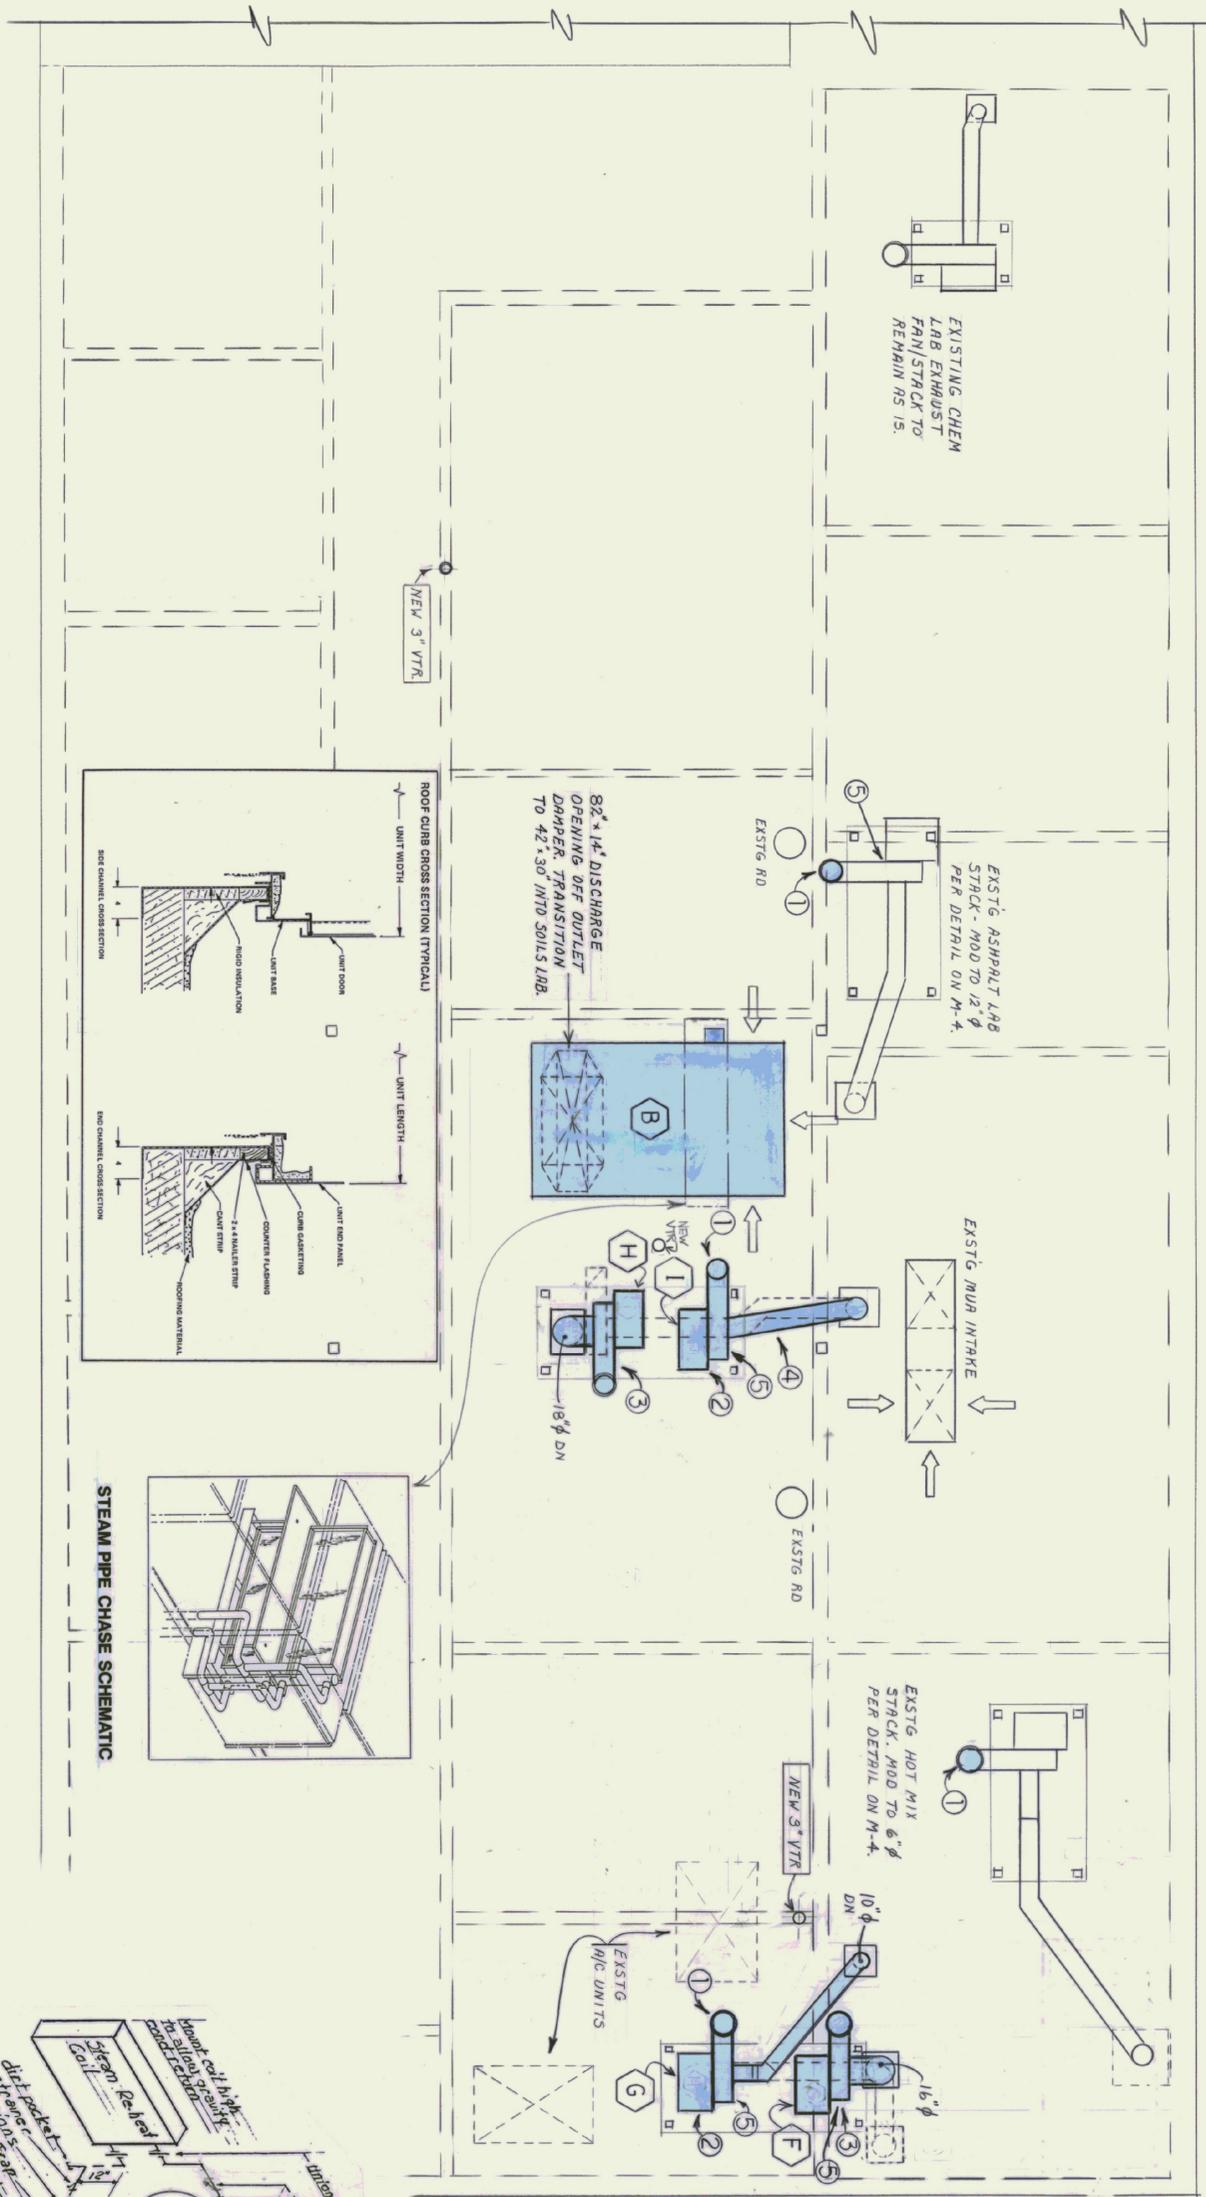
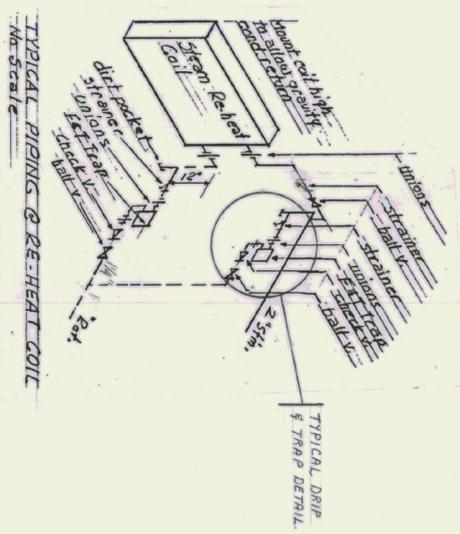


- MECHANICAL WORK NOTES:**
- 1 Existing exhaust stack to be modified per stack detail on M-4.
 - 2 Existing exhaust fan to be re-used.
 - 3 New exhaust fan and stack per details and schedule on M-4.
 - 4 Modify existing Asphalt lab exhaust duct to suit new location of fan "1".
 - 5 Modify fan to Non-Spark Construction by replacing existing ferrous bell and wheel and replacing with aluminum bell and wheel. Consult Buffalo Forge.

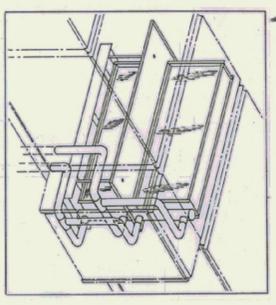

NOTE:
SEE STACK DESIGN
DETAILS & CHART
ON M-4.

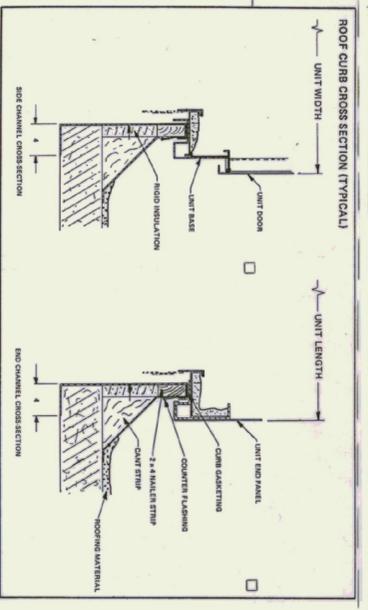

ROOF PLAN
Scale 1/4" = 1'-0"

MECHANICAL CONSULTANT:

GWR Engineering, P.C.
PO Box 157 - The Cannery Building
Shelburne, VT 05482
Tel (802) 985-8081 FAX (802) 985-4499



Materials & Research

Laboratory
Berlin, Vt.

PHASE III

ARCHITECT:

Janson Design, Inc.
FRD KEL ARCHITECT
PO. BOX 55 - BOSTON
(603) 242-2800

PHASE III FLOOR PLAN

ROOF

MECHANICAL PLAN

1-10-91

M-10

2 OF 4