

REV #1 6.14.90  
 REVIEWED ELECTRIC CONDUIT  
 TO TRAFFIC SHOP  
 FROM LOT 105  
 APPROX HENNER & GILV BARR  
 F.V.

REVISIONS: Δ - AS-BUILTS REV. DEC. 1991

State of Vermont  
 Department of State Buildings  
 John Zampieri, Commissioner



Materials & Research  
 Laboratory  
 Berlin, Vt.  
 PHASE II



Johnson Design, Inc.  
 FRED RED, ARCHITECT  
 P.O. BOX 55 - Berlin, VT 05602  
 (802) 244-9800

SITE PLAN #  
 UTILITIES  
 AS-BUILTS MERLE MILLER  
 12/9/91

DATE: APRIL 20 1990  
 DWG. NO. S1

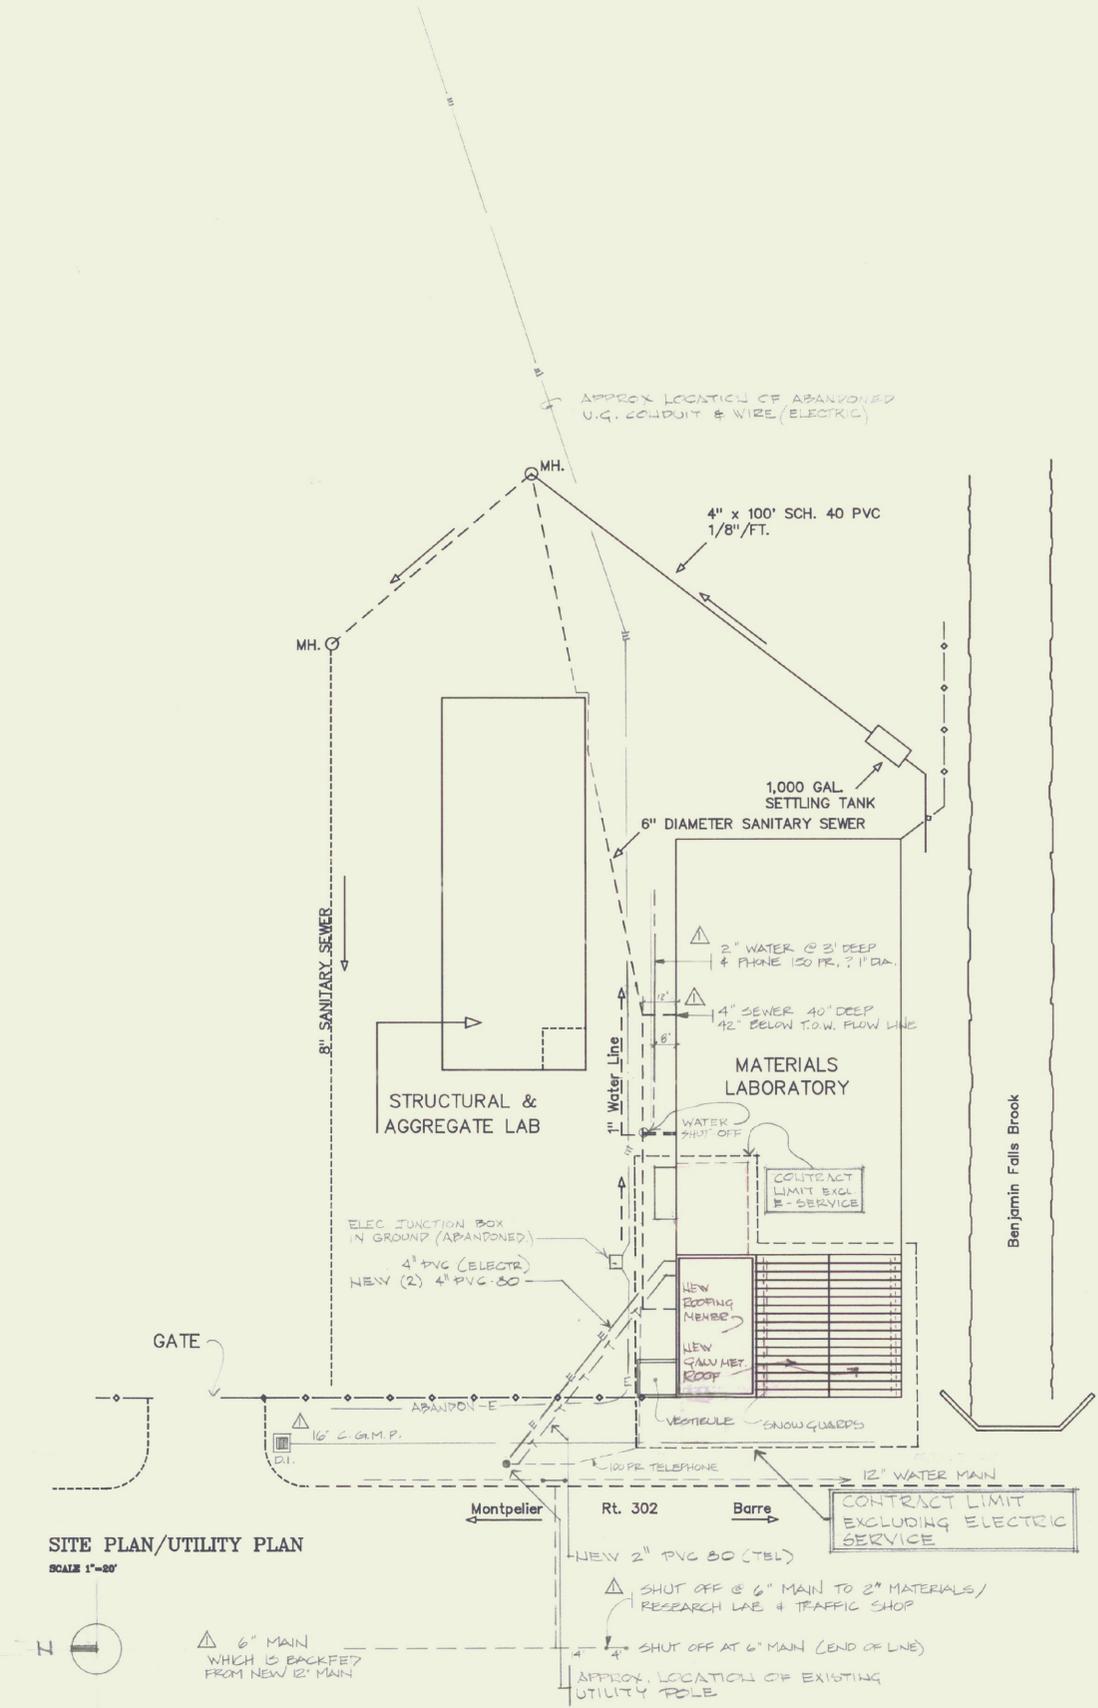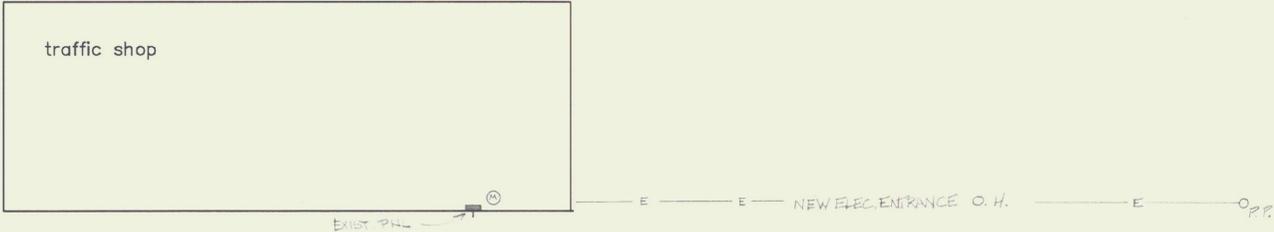

SITE PLAN/UTILITY PLAN  
 SCALE 1"=20'

NOTE: - TELEPHONE (150 PARS) 12/5/91

THE EXISTING TELEPHONE LINE AT THE TIME LEADS FROM THE POLE FOLLOWS THE EDGE OF THE BLACKTOP AND GOES JUST OUTSIDE THE RESEARCH LAB VESTIBULE FOOTING ABOUT 24" DEEP THEN RUNS PARALLEL TO THE AGGREGATE LAB / MATERIALS BLDG. WALLS DOWN THE DRIVE.

POWER TRAFFIC SHOP (ABANDONED 3/91)

(3) 4" Ø JACKETED W/ GROUND PARALLELS THE FENCE OUTSIDE THE COMPLEX NEXT TO RT 302 THEN LOOPS OUT AND RUNS BETWEEN THE FRONTIER TIRE SHOP FOUNDATION WALL AND THE NEW RESEARCH LAB VESTIBULE FOOTING. IT IS BURIED ABOUT 30" DEEP RIGHT UNDERNEATH THE TELEPHONE CABLE. THE POWER FEED TIES INTO A "TIE RIM" JUNCTION BOX UNDER AND THE SHOP LOCATION THEN FEEDS DOWN TO THE TRAFFIC SHOP.