



NOTE: RADIATION ENCLOSURE WIDTH = 5'-1 1/16"
SEE M-6 FOR TYPICAL PIPING @ RAD.

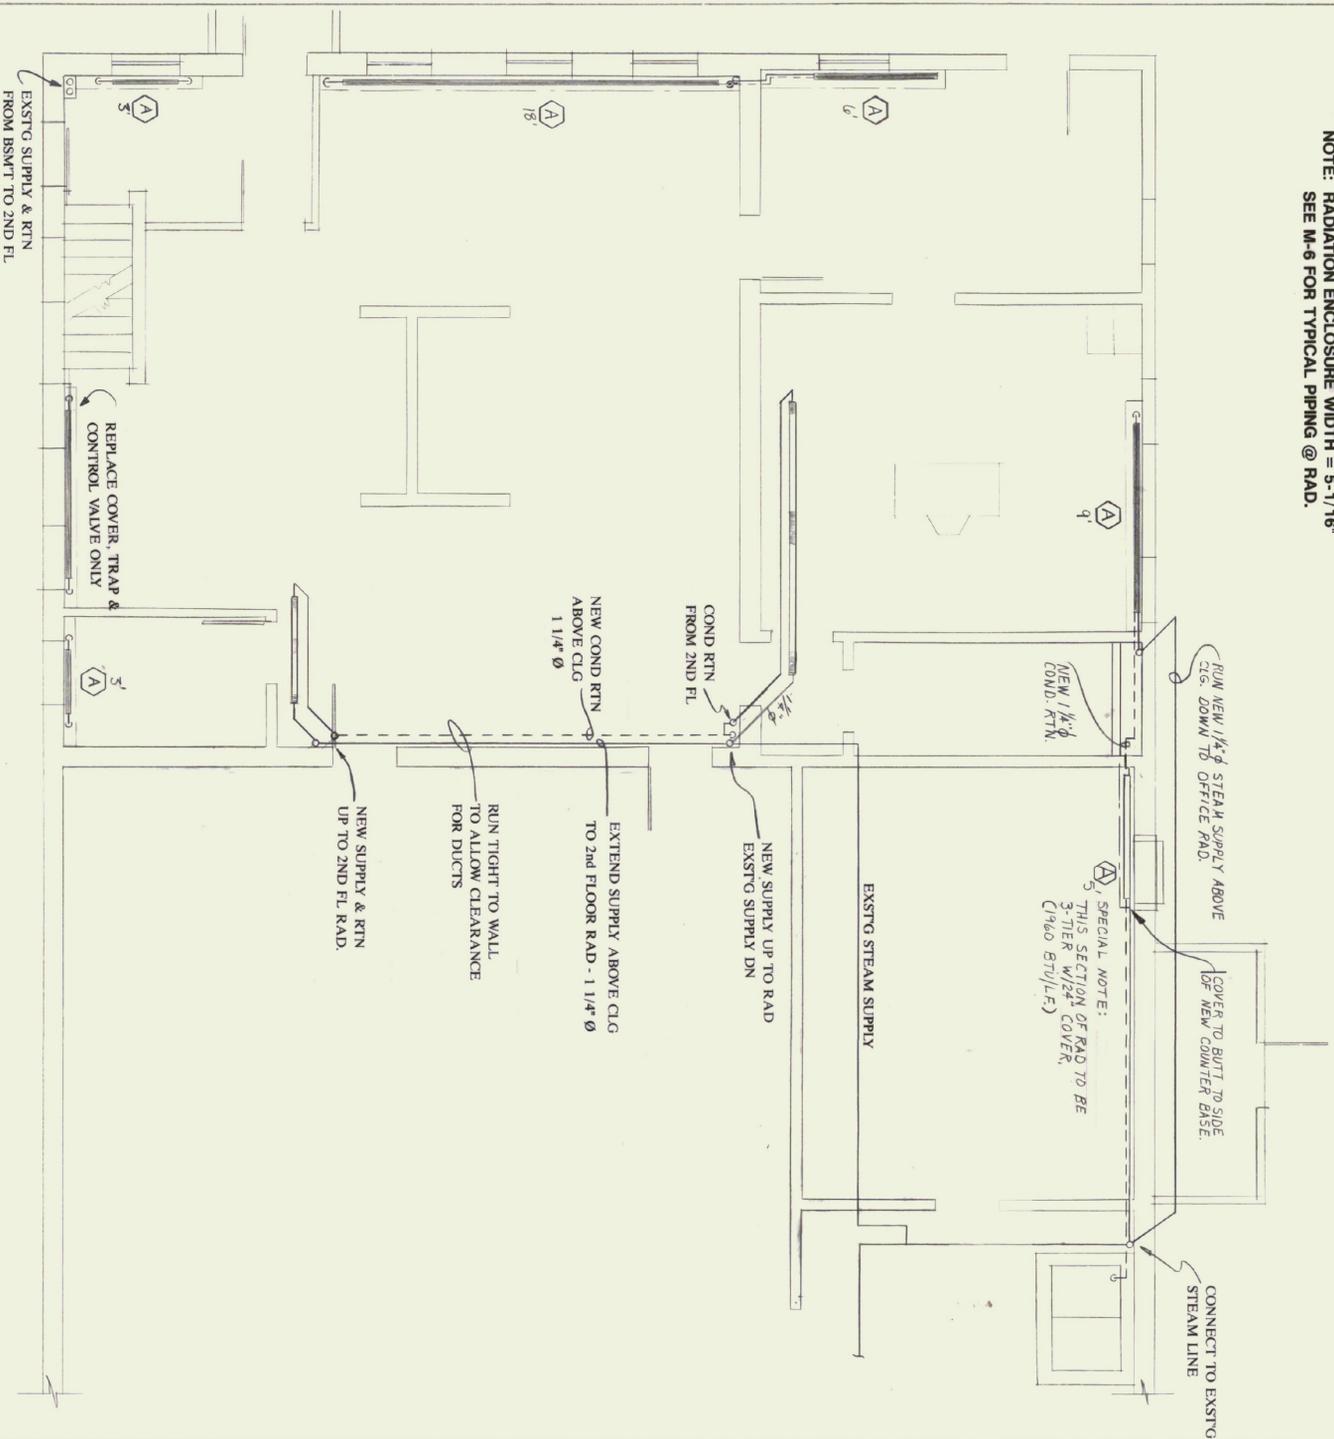

First Floor Plan
Scale: 1/4" = 1'-0"

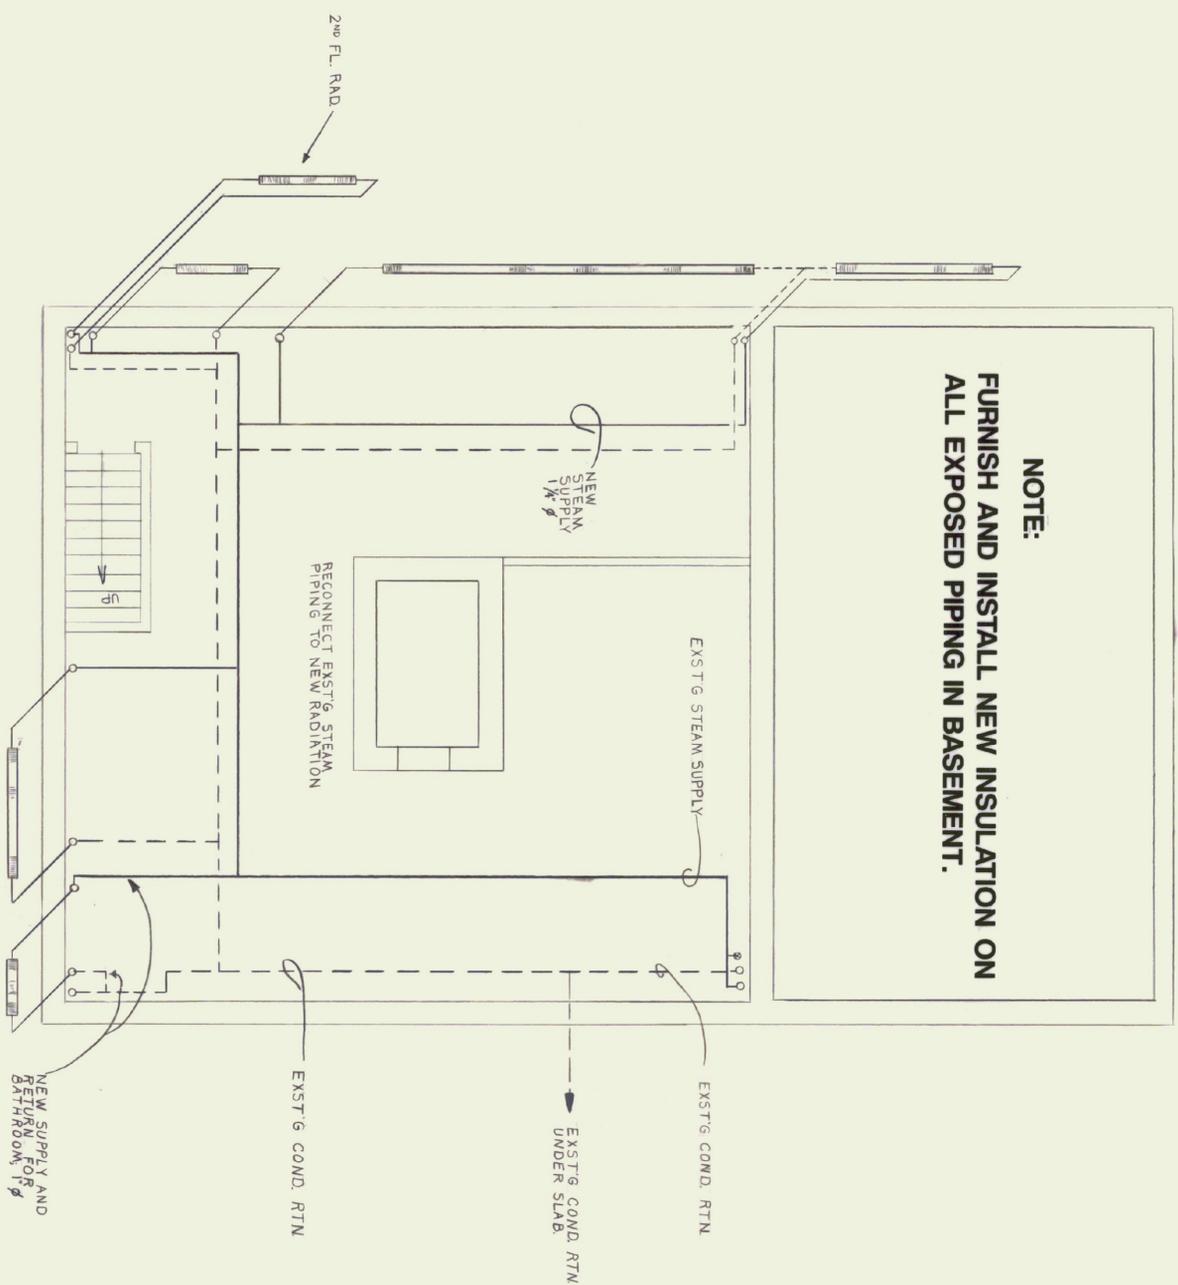

Basement Floor Plan
Scale: 1/4" = 1'-0"



MECHANICAL CONSULTANT:

GWR Engineering, P.C.
PO Box 157 - The Cannery Building
Shelburne, VT 05482
Tel (802) 985-8061 FAX (802) 985-8499

ARCHITECT:

Janson Design, Inc.
RED KILL ARCHITECT
P.O. BOX 55 - RD. 203, 244-5800
DUNSTON, VT 05251

State of Vermont
Department of State Buildings
John Zampieri, Commissioner

MATERIALS & RESEARCH LABORATORY

Berlin, VT
Phase 2

MECHANICAL SYSTEMS - HEATING

DATE:

4-20-'00

DWG. NO.

M-5