



PLUMBING FIXTURE NOTES:

- 1 INSTALL NEW HANDICAPPED LAVATORY & FAUCET PER ANSI A117.1-1986:
 AMERICAN STANDARD WALL HUNG LAVATORY, LUCERNE MODEL 0355-012 FOR
 CONGEALD ARMS - WHITE. MOUNT TO OBTAIN RIM HEIGHT = 34" OFF
 FLOOR. FURNISH AND INSTALL SYMONS SINGLE LEVER FAUCET,
 MODEL #S-90-2-G-FR-W.
 CARRIER: ZURN MODEL Z-1231
 STOPS & TRAPS: INSTALL NEW ANGLE STOPS FOR FLEXIBLE RISERS.
 RE-PIPE NEW 1-1/2" SAN.
 INSULATION: INSULATE ALL PIPING UNDER LAV. WITH 1/2" ARMAFLEX
 REPLY TAPED ON.


- 2 INSTALL NEW WATER CLOSET PER ANSI A117.1-1986 HANDICAPPED STANDARDS:
 AMERICAN STANDARD FLOOR MOUNT, TANK TYPE, CAPET FLOATED WATER
 SAVER TOILET MODEL #2108.408 - WHITE. PROVIDE BEMIS DURALOT SEAT,
 ENLARGATED, OPEN FRONT, LESS COVER. MODEL #1955-C.

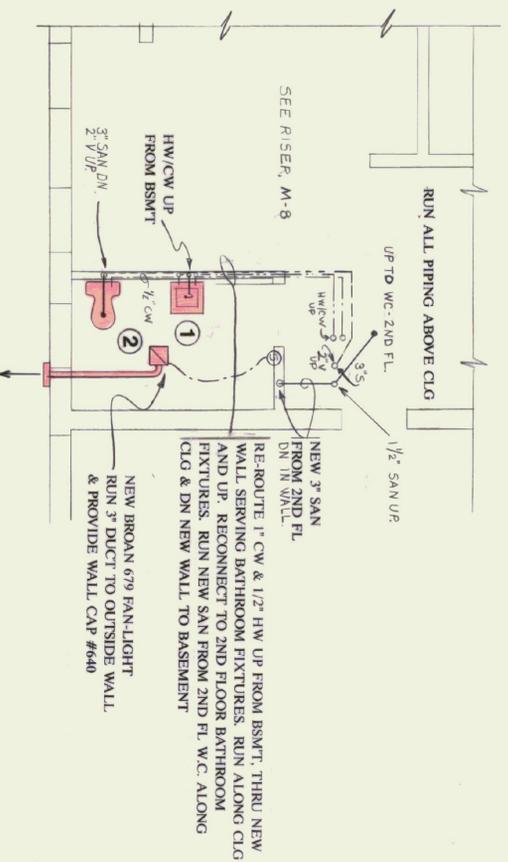

Partial First Floor Plan T.R.
 Scale 1/4" = 1'-0"

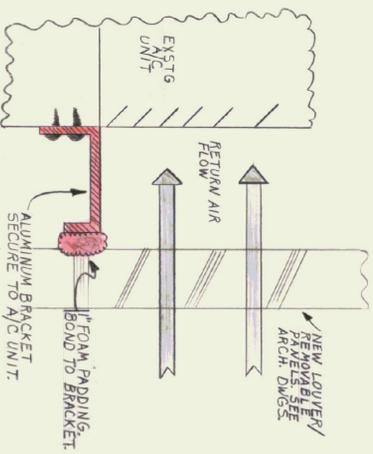

Partial First Floor Plan - A/C
 Scale 1/4" = 1'-0"

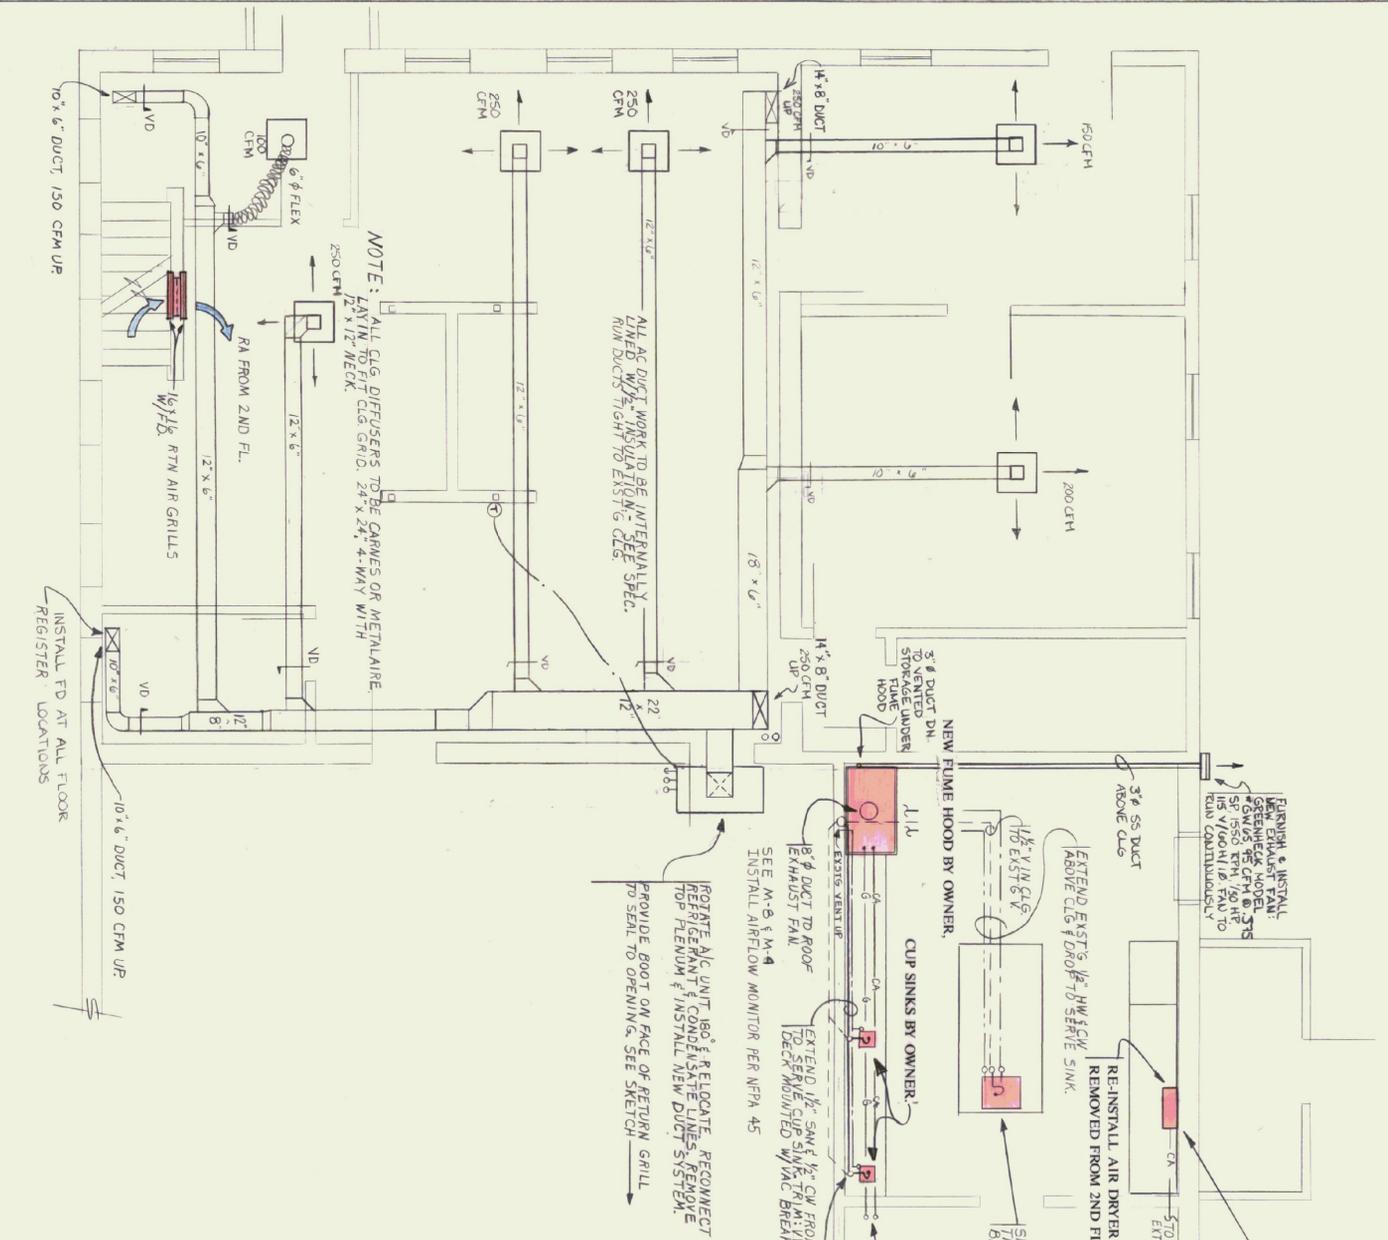

MECHANICAL CONSULTANT:

ARCHITECT:

GWR Engineering, P.C.
 P.O. Box 157 - The Community Building
 Shelburne, VT 05482
 Tel (802) 985-8061 FAX (802) 985-8499

Janson Design, Inc.
 FRED TOLLE ARCHITECT
 8020 ROAD, WATERBURY, VT 05678
 (802) 244-8800

State of Vermont
 Department of State Buildings
 John Zampieri, Commissioner

MATERIALS & RESEARCH LABORATORY

Berlin, VT
Phase 2

MECHANICAL SYSTEMS -
First Floor Plan

New Work

AIR CONDITIONING
 VENTILATION
 PLUMBING

DATE: 4-20-90
 DWG. NO. M-7

