

NOTE: STACKS AND DUCT WORK ON ROOF TO BE PROTECTED FROM DEMO BY MFS

SEE M-4 FOR ROOF LOCATION



Roof Fan & Stack Details

No Scale




San Piping Riser Diagram - Toilet Rooms

No Scale

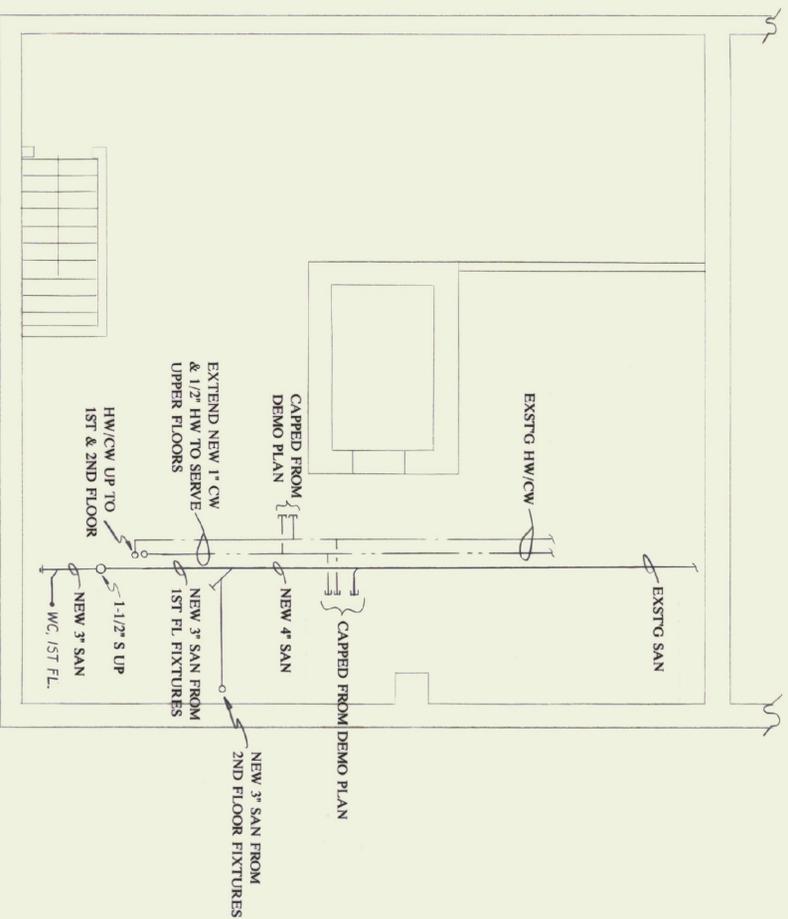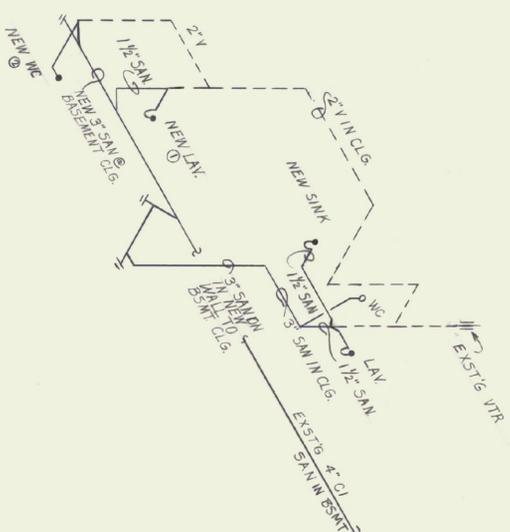

Basement Floor Plan

Scale 1/4" = 1'-0"

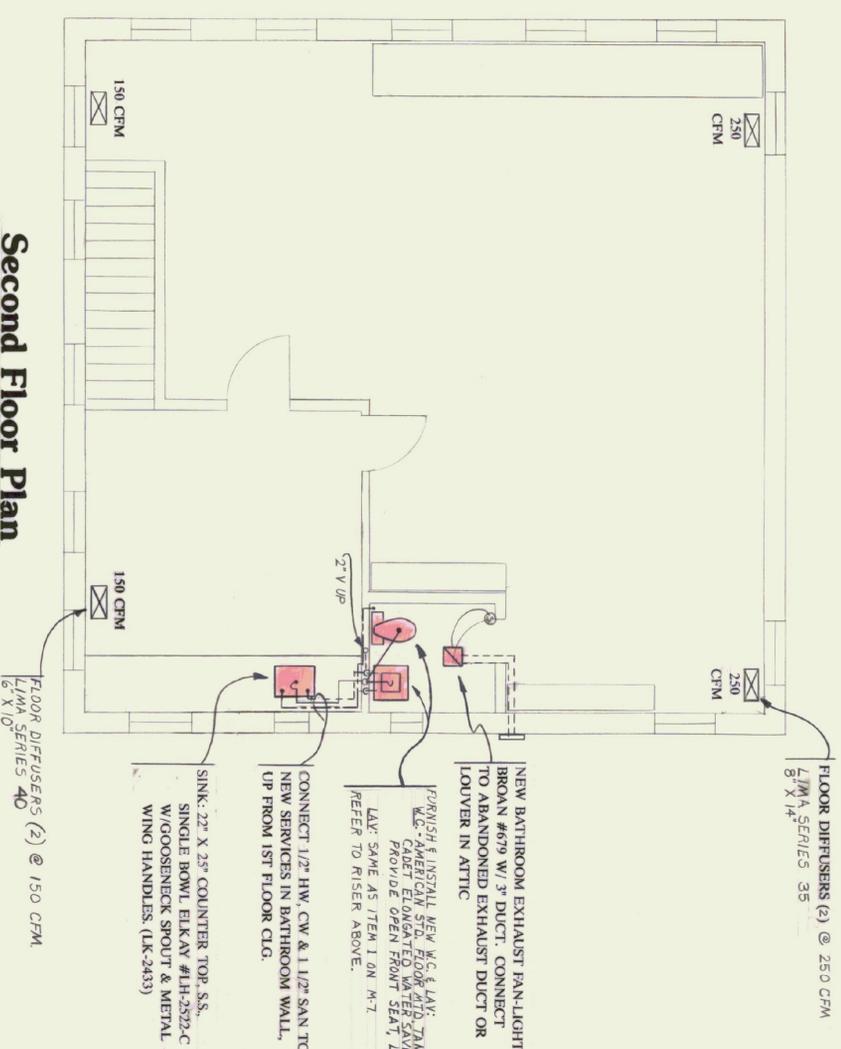

Second Floor Plan

Scale 1/4" = 1'-0"



MECHANICAL CONSULTANT:

GWR Engineering, P.C.
PO Box 137 - The Community Building
5th Floor
7th (802) 985-8001 FAX (802) 985-8499

ARCHITECT:

Janson Design, Inc.
FRED KELL ARCHITECT
PO. BOX 58 - BAXTON ROAD, WATTSBORO, VT 05678
(802) 244-5850

State of Vermont
Department of State Buildings
John Zampieri, Commissioner

MATERIALS & RESEARCH LABORATORY

Phase 2

MECHANICAL SYSTEMS -

Basement &
Second Floor Plans

AIR CONDITIONING
VENTILATION
PLUMBING
New Work

DATE:

4-20-90

DWG. NO.

M-8