


State of Vermont
 Agency of Transportation
 Paul R. Philbrook, Secretary

Renovations To The
 Materials & Research Laboratory
 Of The
 Agency of Transportation Complex
 Berlin, Vermont

PHASE I


INDEX TO DRAWINGS

TITLE SHEET	E1	DEMOLITION & LIGHTING PLAN
REFERENCE PLAN	E2	POWER PLAN
EQUIPMENT LAYOUT	M1	DEMOLITION, H&V PLAN
FOUNDATION & FRAMING PLAN	M2	PLUMBING PLAN, SCHEDULES
FLOOR PLAN		
BUILDING ELEVATIONS, SECTIONS		
WALL SECTIONS		
D1 TYPICAL DETAILS		

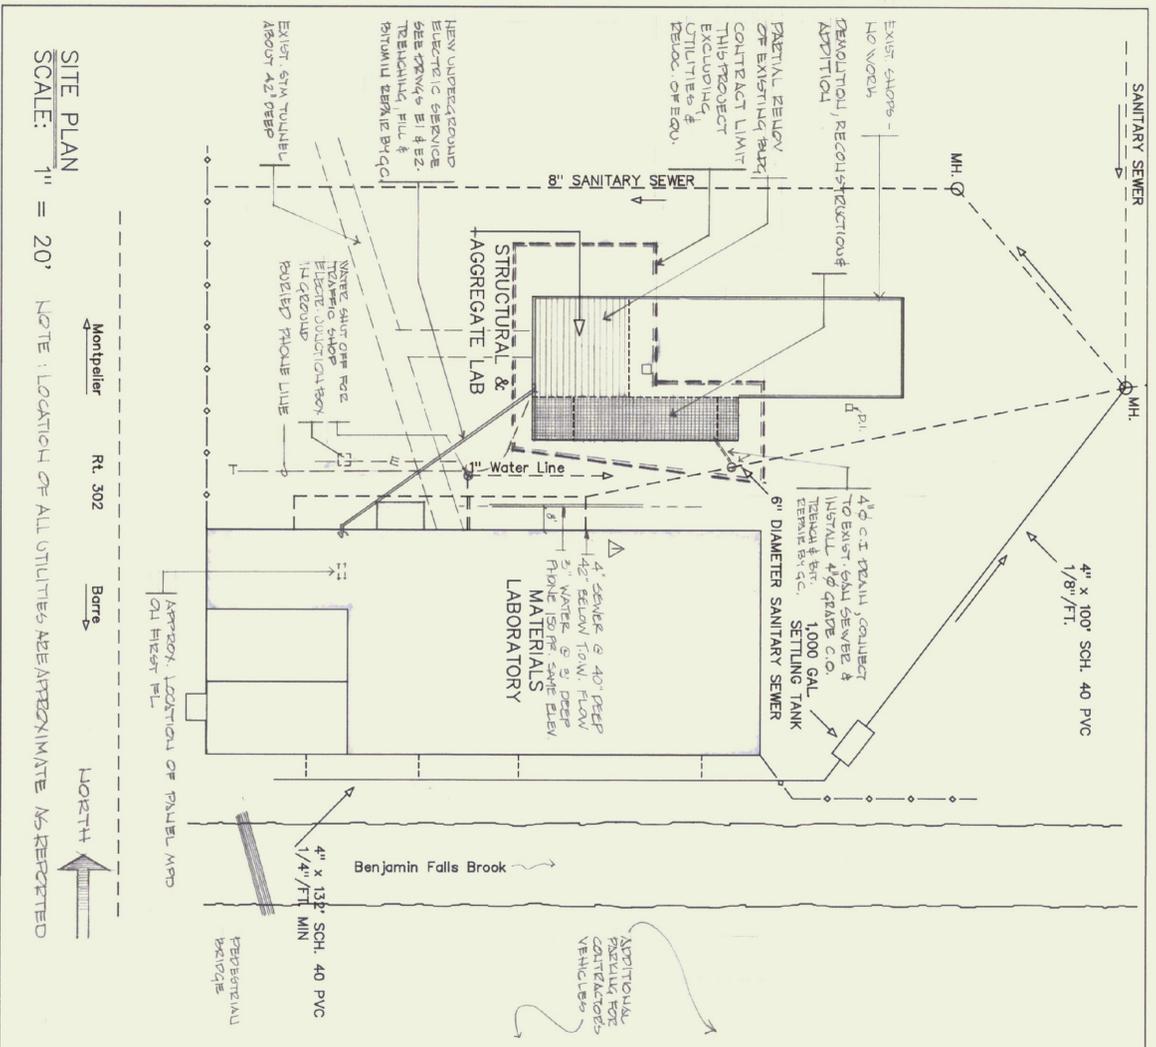

SITE PLAN
 SCALE: 1" = 20' NOTE: LOCATION OF ALL UTILITIES ARE APPROXIMATE AS RECEIVED

NOTE: CONTRACTOR SHALL INSTALL MARKING TAPE ON TOP OF ALL NEW BURIED UTILITY LINES. (WATER, SEWER, ELECTRIC, FIBER, ETC.)

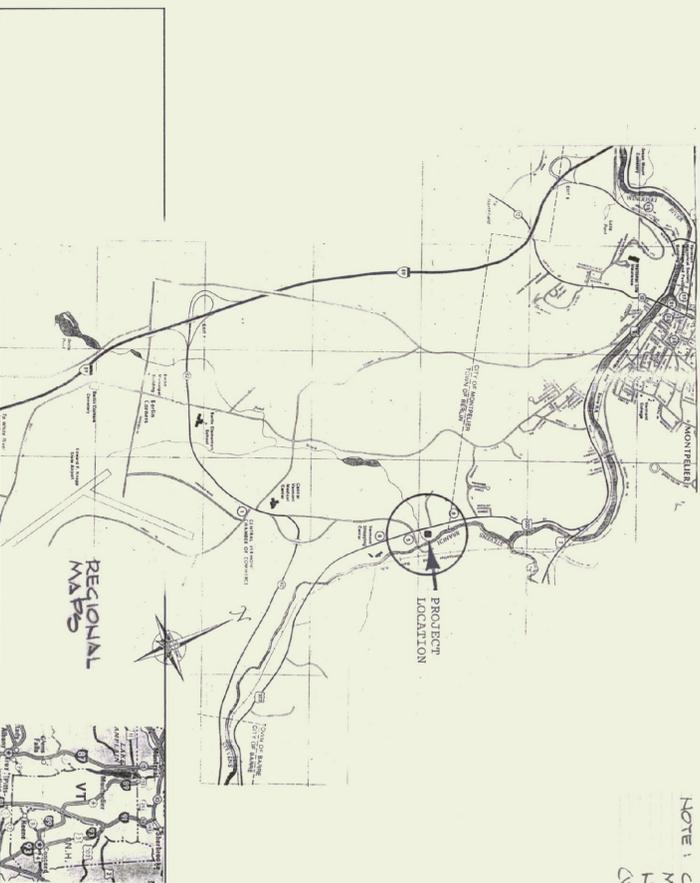

State of Vermont
 Department of State Buildings
 John Zampieri, Commissioner

Materials & Research Laboratory Berlin, VT		Janson Design, Inc. P.O. BOX 55 - FRED K. JANSON ARCHITECT 1000 Rte. 100 - Barre, Vermont 05876 (802) 244-5800	TITLE SHEET REV. NOV. 1989 REV. - Δ AS BUILTS DEC. 1991	DATE: OCT. 10, 1989 DWG. NO.
---	--	---	--	------------------------------------