





NOTES:
1. BONDING CONDUCTOR IS NOT SHOWN
2. SIMILAR FOR ALL TOE SPACE HEATER(S) AND CABINET HEATERS (CH)

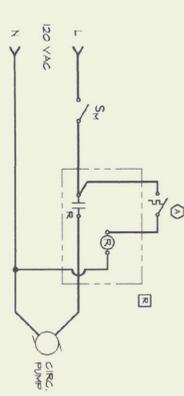

NOTES:
1. BONDING CONDUCTOR IS NOT SHOWN
2. SIMILAR FOR PUMP P2

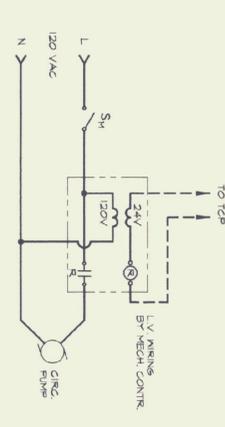

NOTES:
1. BONDING CONDUCTOR IS NOT SHOWN
2. SIMILAR FOR ALL HEATING ZONE CIRC. PUMPS P1 & P2

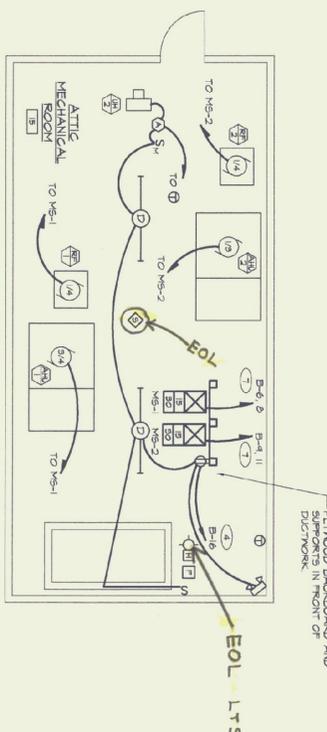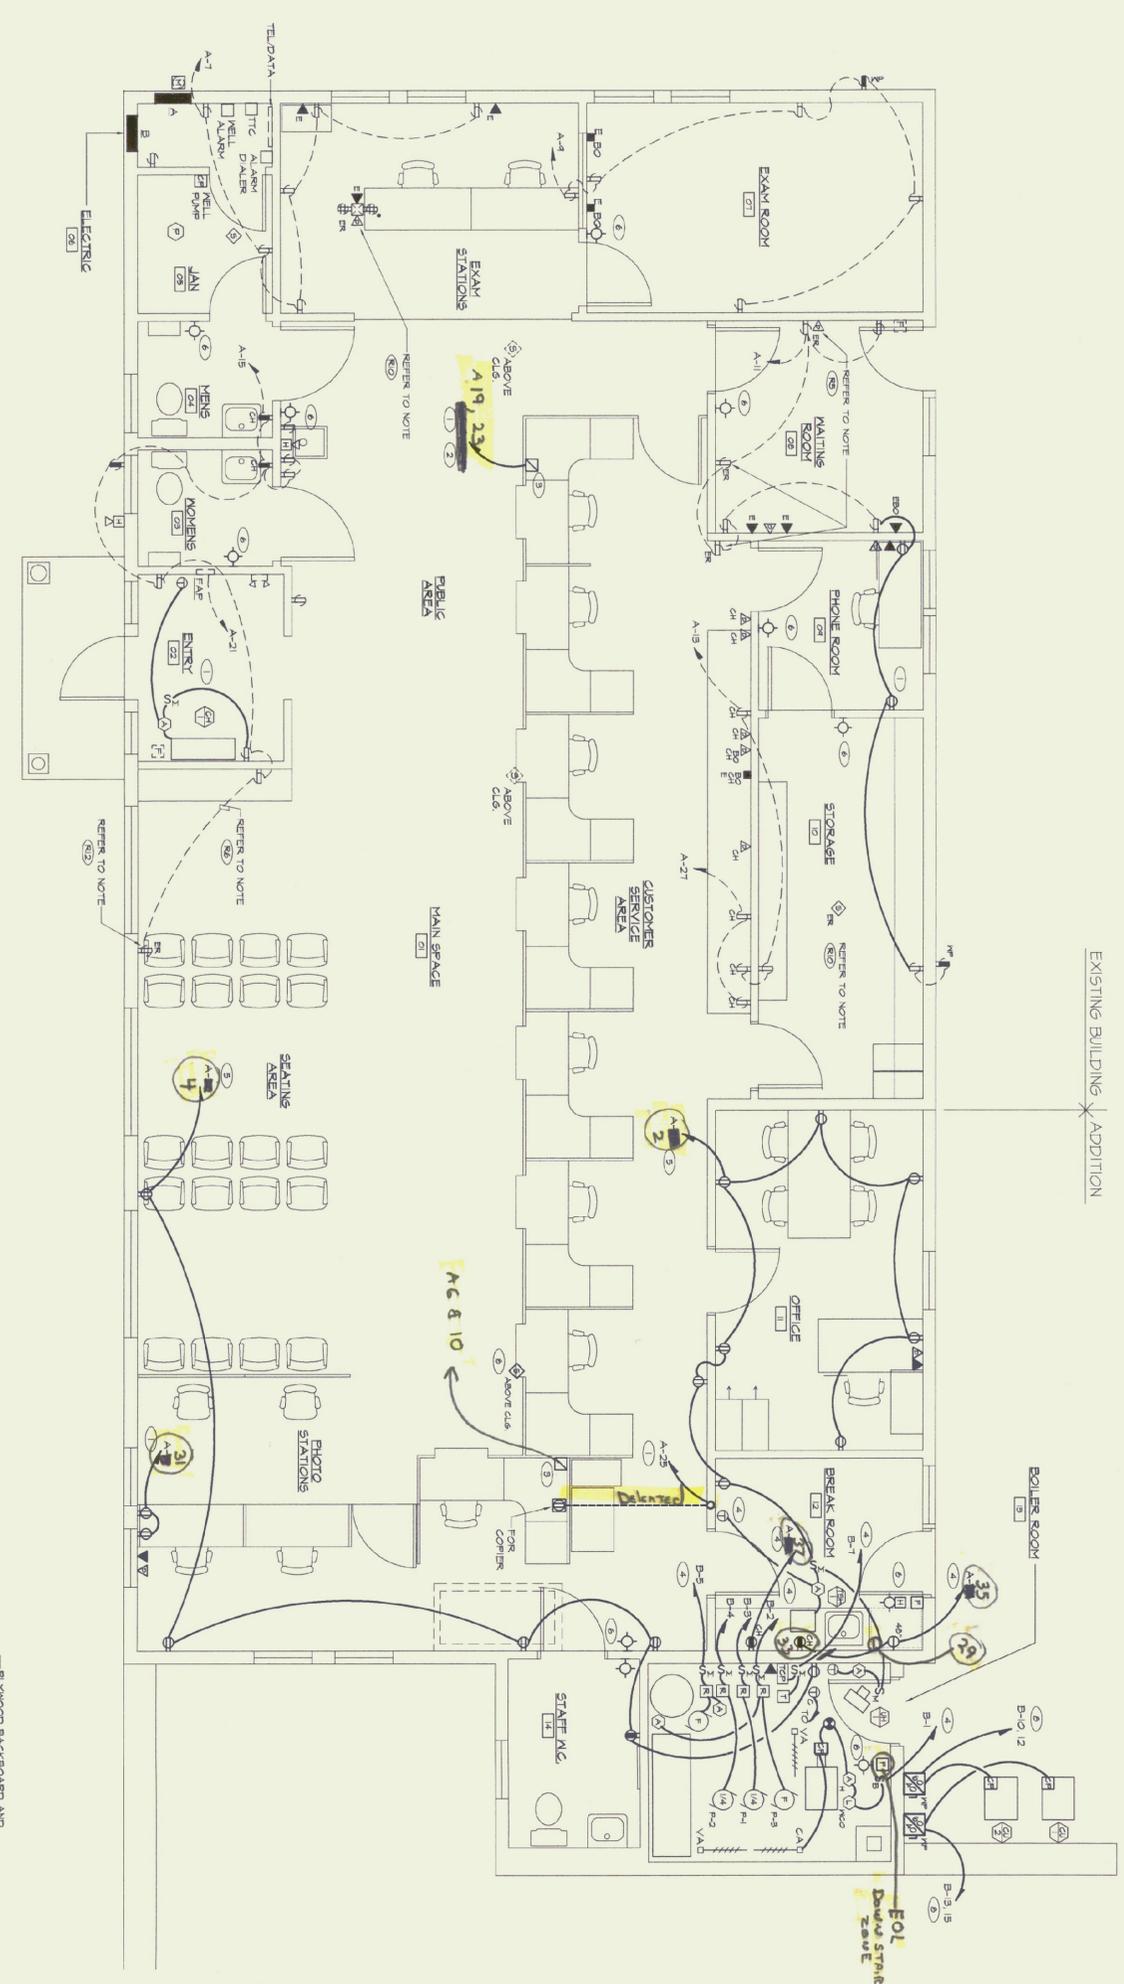

AS-BUILT



ERTEL ASSOCIATES ARCHITECTS
15 CENTRAL STREET WOODSTOCK, VERMONT 05091
LANE ASSOCIATES CONSULTING ENGINEERS
51 KILINGTON AVENUE RUTLAND, VERMONT 05701

DEPARTMENT OF MOTOR VEHICLES RUTLAND - RENOVATION & ADDITION
MAIN FLOOR PLAN - POWER & SIGNAL

SCALE: AS NOTED
DATE: MAY 2000
REVISIONS:
JOB #:
ACT. CAPD #:
BY: JDL/BJL
THE STATE OF VERMONT
CHARLES F. BROWN
REGISTERED PROFESSIONAL ENGINEER
NO. 4110
E2