




**FIRST FLOOR PLAN - PLUMBING**  
 SCALE: 1/4" = 1'-0"

**FIXTURE SCHEDULE**

| FIXTURES        | SOIL   | WASTE  | TRAPS  | VENT   | TRAP |
|-----------------|--------|--------|--------|--------|------|
| WATER FLOORS    | 4"     |        |        |        | INT. |
| BATHS           | 2"     | 1"     | 1 1/2" | 1 1/2" | INT. |
| LAVATORY        | 1 1/2" | 1 1/2" | 1 1/2" | 1 1/2" | INT. |
| HYD. BATH       | 1 1/2" | 1 1/2" | 1 1/2" | 1 1/2" | INT. |
| BATH            | 1 1/2" | 1 1/2" | 1 1/2" | 1 1/2" | INT. |
| DRINK. FOUNTAIN | 1 1/2" | 1 1/2" | 1 1/2" | 1 1/2" | INT. |
| LAB. SINK       | 1 1/2" | 1 1/2" | 1 1/2" | 1 1/2" | INT. |

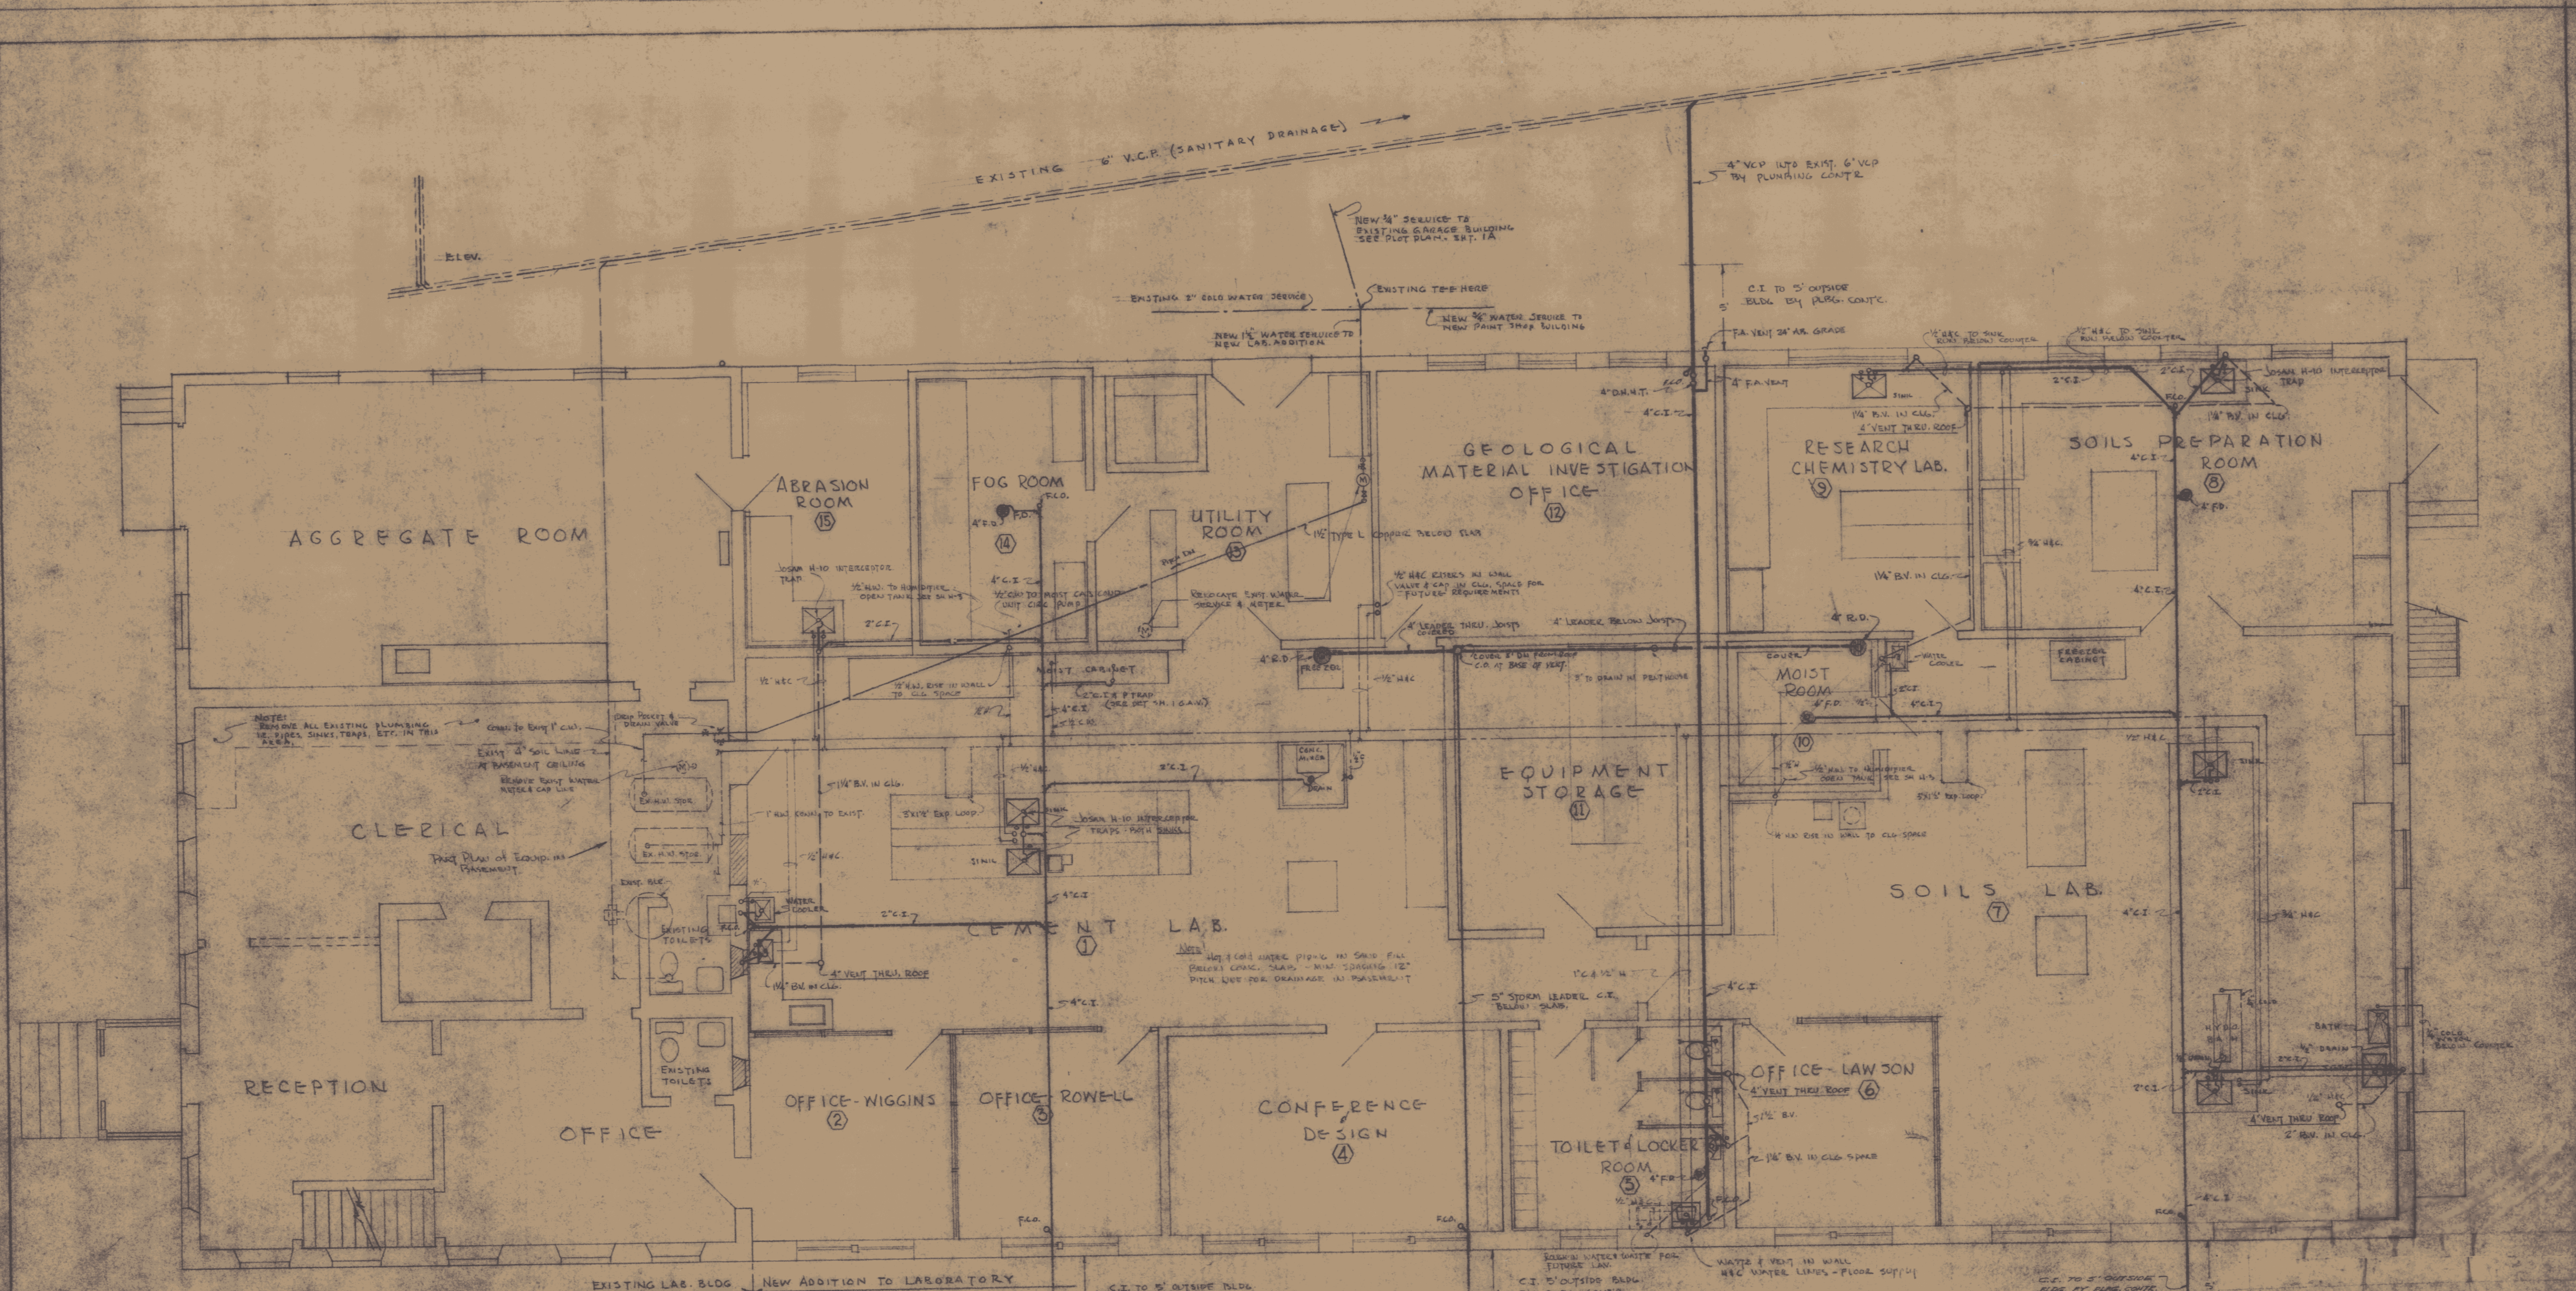

**JENNISON ENGINEERING INC.**  
 25 COLLEGE ST. BURLINGTON, VT.

**ADDITION TO VERMONT STATE HIGHWAY LABORATORY**  
 MONT PELLEE, VERMONT

**GORDON G. WOODS**  
 REGISTERED PROFESSIONAL ENGINEER  
 ST. JOHNSBURY, VERMONT