



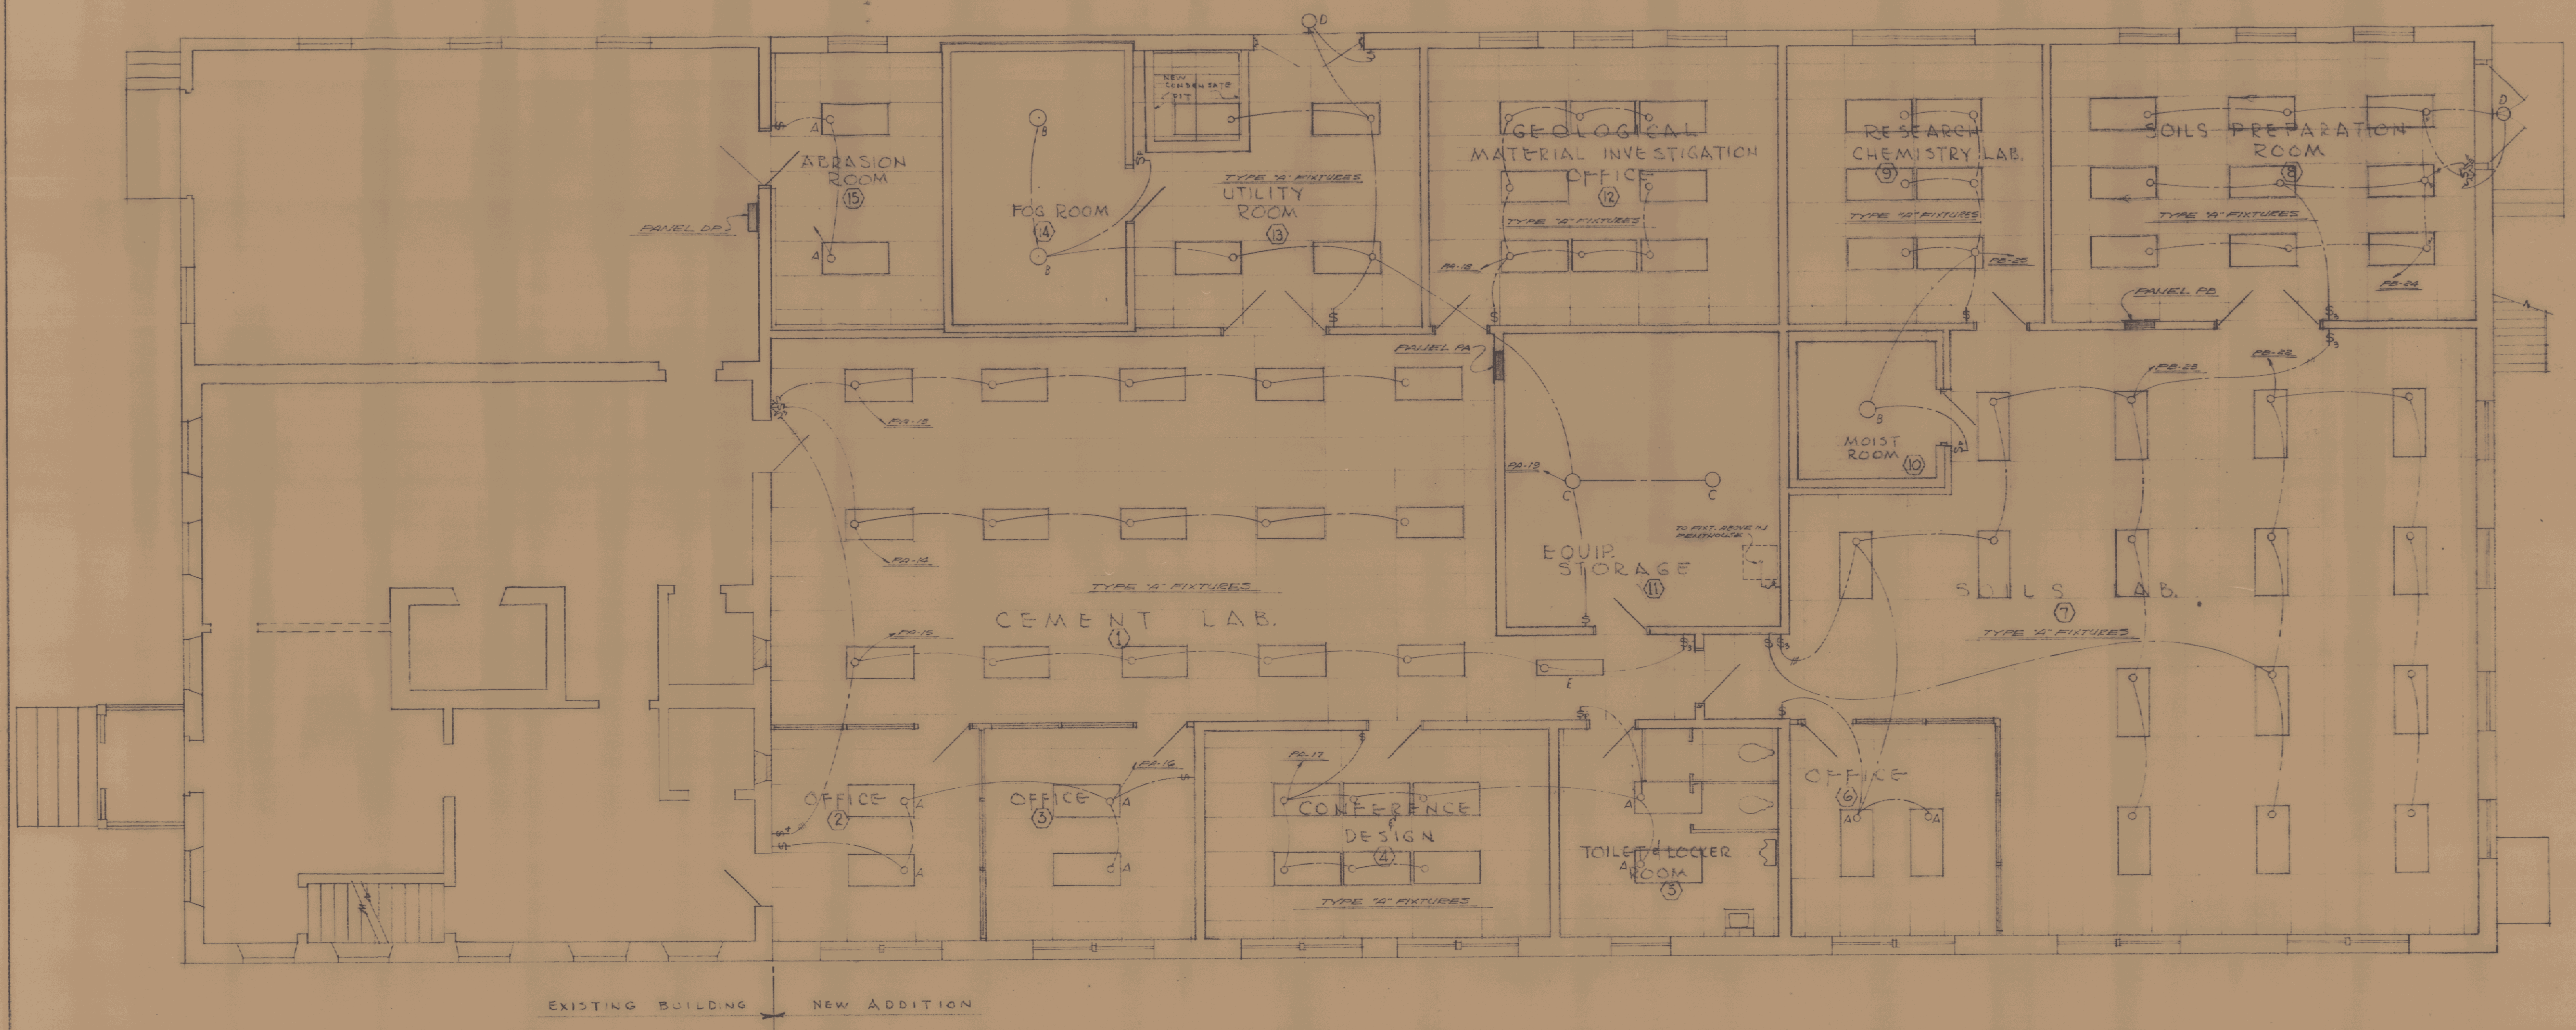

FIRST FLOOR PLAN - ELECTRICAL LIGHTING LAYOUT

SCALE: 1/4" = 1'-0"

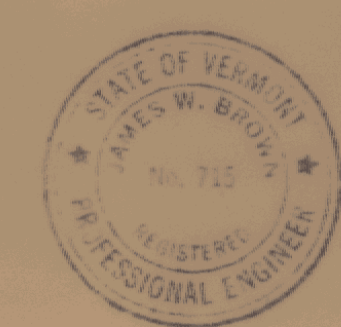

JENNISON ENGINEERING INC.	
95 COLLEGE ST.	BURLINGTON, VT.
ADDITION TO VERMONT STATE HIGHWAY LABORATORY	
MONTPELIER, VERMONT	
GORDON G. WOODS	DATE: MAR '61
ARCHITECT	PROJECT NO. 602
ST. JOHNSBURY, VERMONT	REVISION: E-2