



RECORD DRAWING

SHOWN PICTORALLY
MAY NOT BE TO SCALE

THESE AS-BUILT OR RECORD DRAWINGS HAVE BEEN PREPARED, IN PART, ON THE BASIS OF INFORMATION COMPILED AND FURNISHED BY OTHERS. THE ENGINEER WILL NOT BE RESPONSIBLE FOR ANY ERRORS OR OMISSIONS WHICH HAVE BEEN INCORPORATED INTO THIS DOCUMENT AS A RESULT OF INFORMATION BY OTHERS.

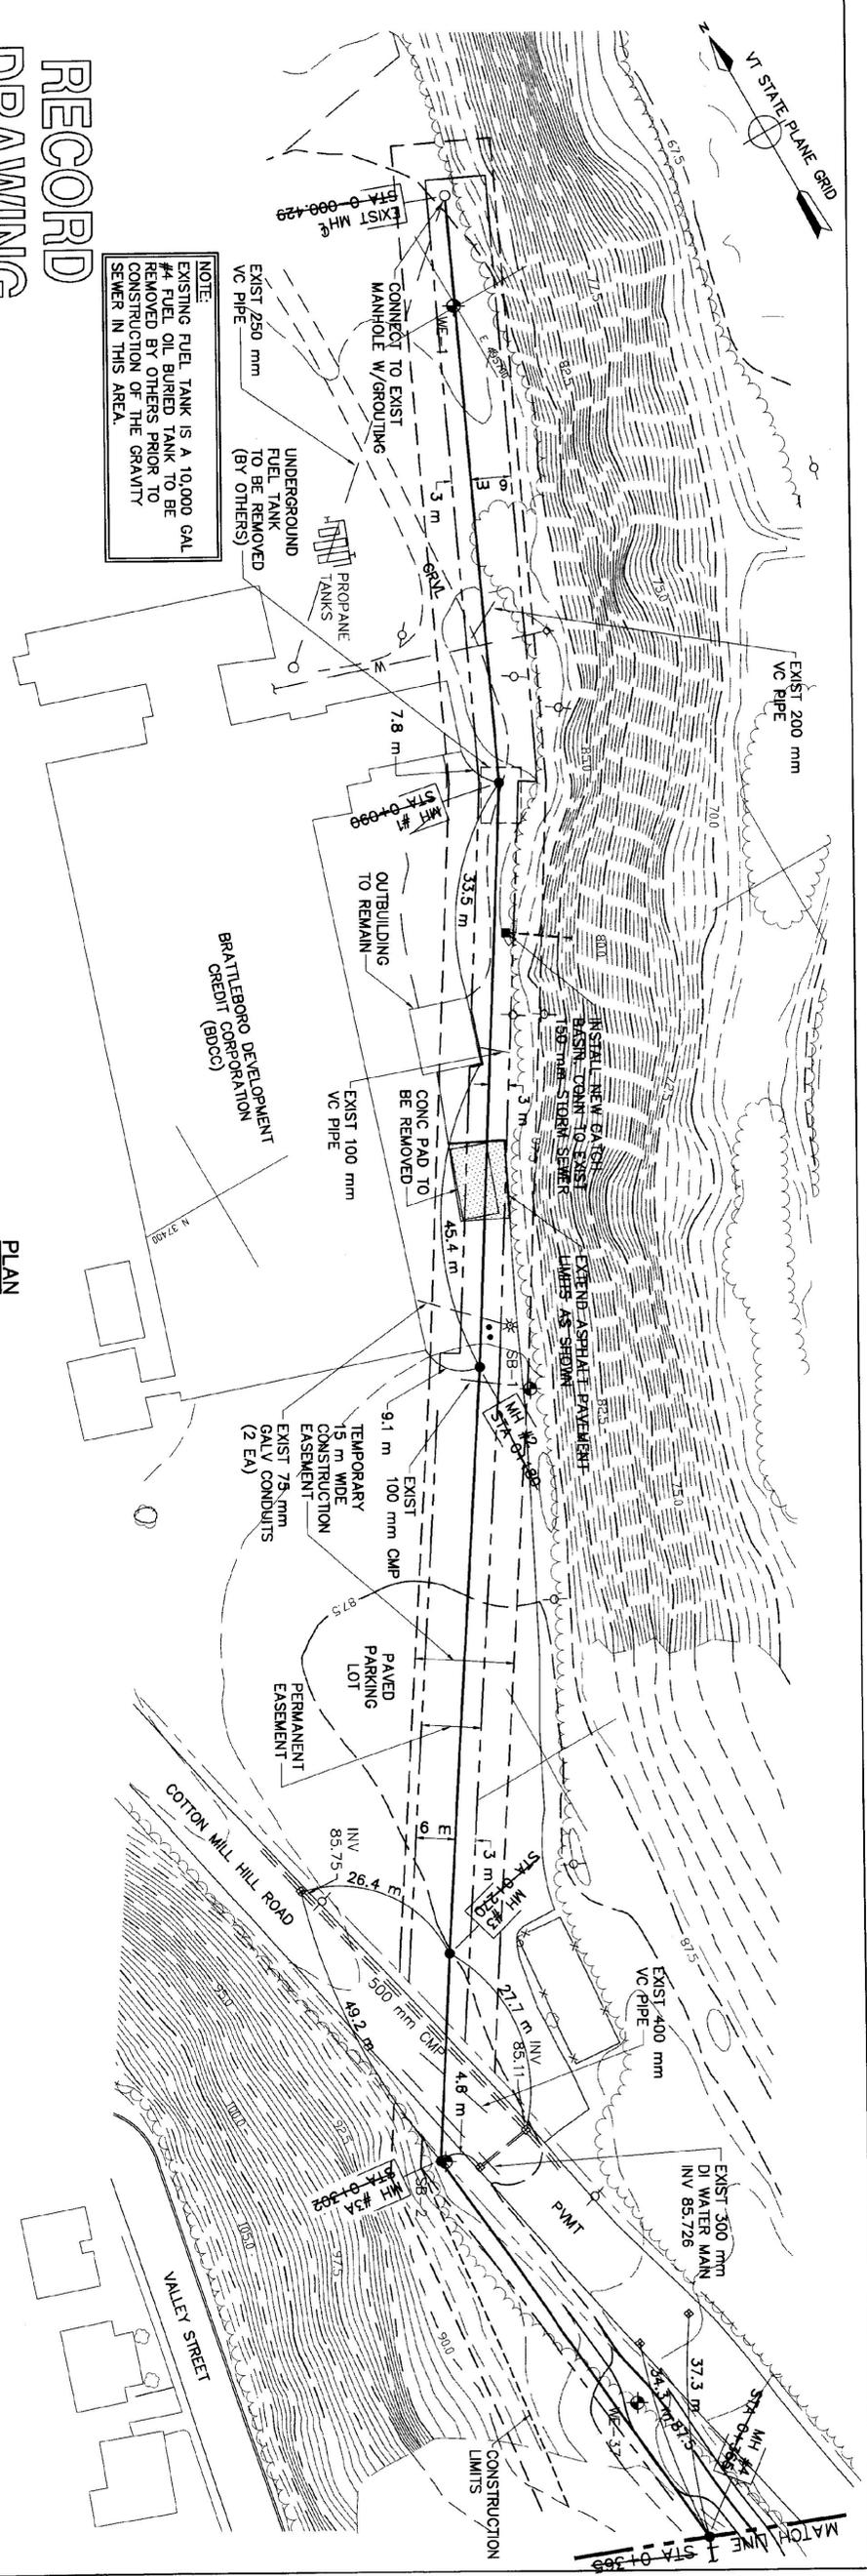

PLAN
SCALE: 1:300

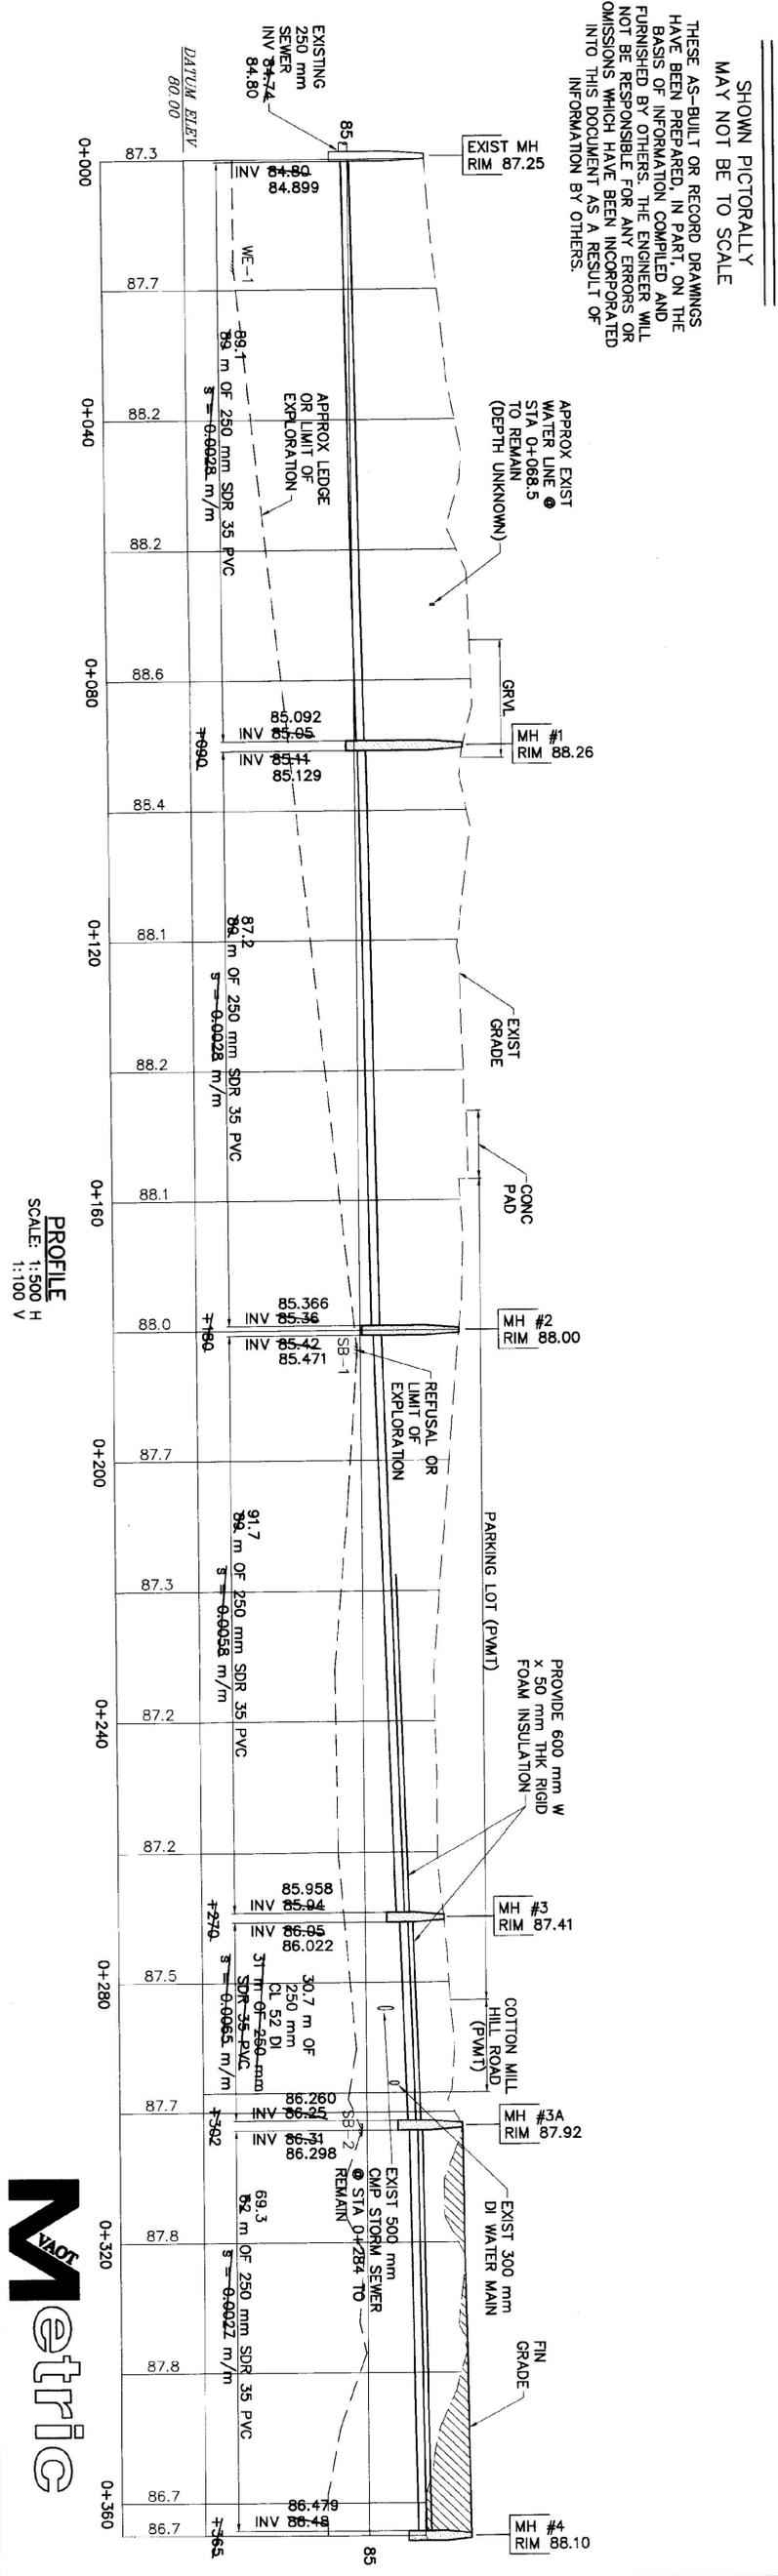



PROFILE
SCALE: 1:500 H
1:100 V

NO.	DATE	REVISIONS	DRWN	CHKD
1	4/8/96	REVISIONS PER REVIEW COMMENTS	DSM	MPY
2	6/4/96	REVISIONS PER REVIEW COMMENTS	DSM	MPY
3	11/1/96	FINAL REVIEW REVISIONS	DSM	MPY
4	12/29/96	CONTRACT PLANS	DSM	MPY
5	9/30/98	AS-BUILT INFORMATION ADDED	DSM	KAS

DESIGN BY:	JAC
DRWN BY:	DSM
CHKD BY:	JAC
DATE:	1-2-96

PROJECT NO. IM 091-1 (29)	PROJECT TITLE: SANITARY SEWER PLAN AND PROFILE
WATER & SEWER EXTENSION PROJECT	
TOWN OF GUILFORD	
TOWN OF BRATTLEBORO	

STATE OF VERMONT	AGENCY OF TRANSPORTATION
SOUTHEAST VERMONT WELCOME CENTER	GUILFORD, VERMONT
SHEET NO. 5	OF 55 SHEETS

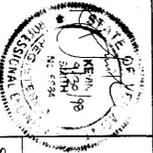 

TIMOTHY D. SMITH & ASSOCIATES, PC ARCHITECTS
NORTH BENNINGTON, VERMONT 05257
FAX 802-442-8241

WRIGHT ENGINEERING, LTD. CIVIL ENGINEERS
RUTLAND, VERMONT 05702-0176
FAX 802-775-8915