




TYPICAL WALL SECTION  
SCALE: 1:20

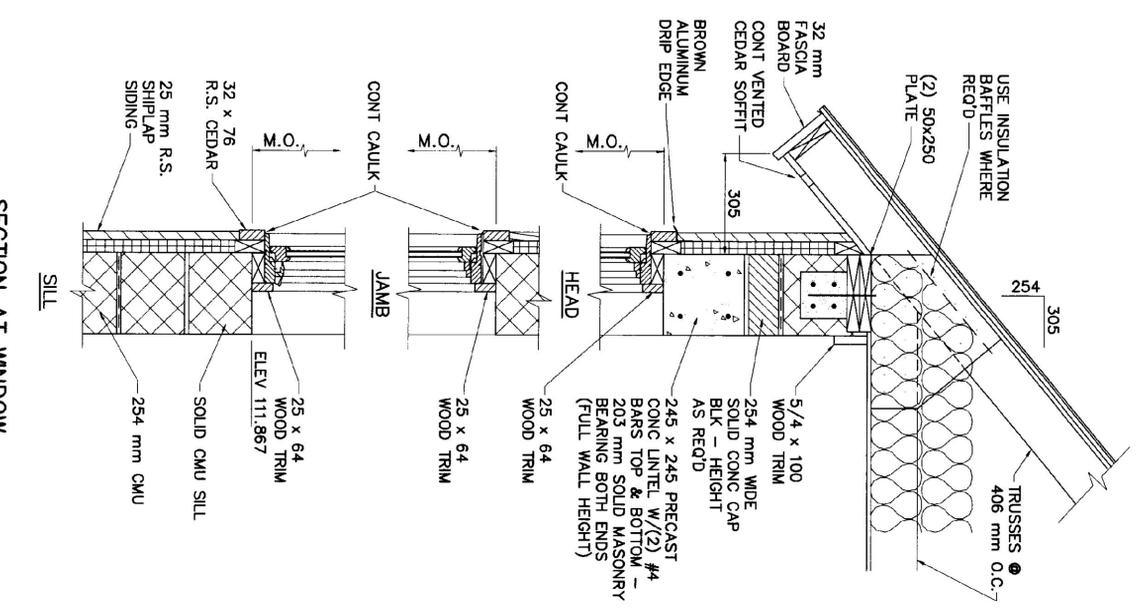

SECTION AT WINDOW  
SCALE: 1:10  
(WINDOW UNTEL WL-1)

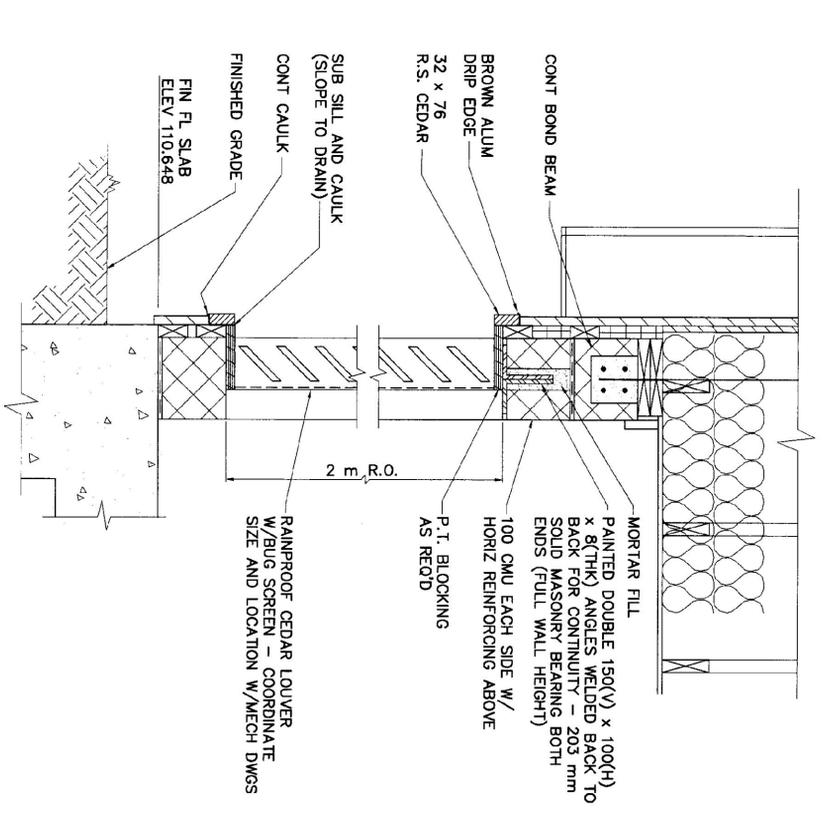


INTAKE LOUVER DETAIL  
SCALE: 1:10

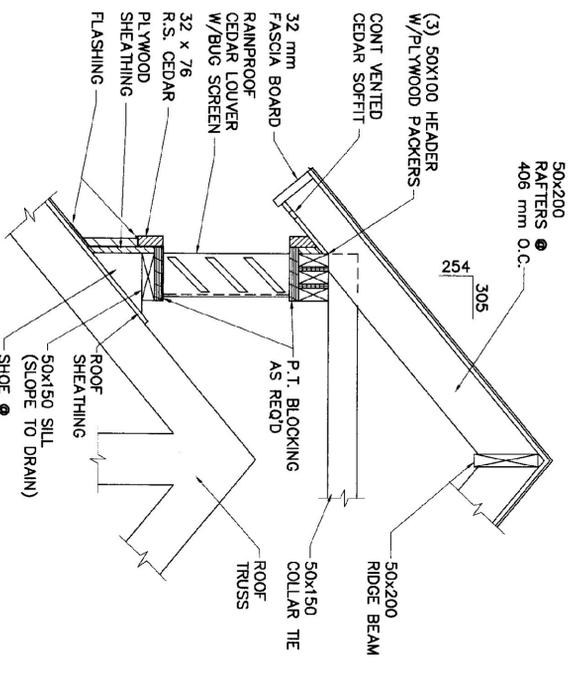

TYPICAL CUPOLA SECTION  
SCALE: 1:10

WINDOW SCHEDULE							
WINDOW MARK	CATALOG NUMBER	MANUFACTURER	ROUGH OPENING WIDTH	ROUGH OPENING HEIGHT	FRAME MATERIAL	UNTEL MARK	REMARKS
A	CAWM 2832	MARVIN	737	827	METAL CLAD	WL-1	

5	9/30/98	NO AS-BUILT INFORMATION ADDED	DSM	KAS	TIMOTHY D. SMITH & ASSOCIATES, PC ARCHITECTS
4	12/28/98	CONTRACT PLANS	DSM	MPY	OLD FAIRROAD STATION
3	11/11/98	FINAL REVIEW REVISIONS	DSM	MPY	NORTH BENNINGTON, VERMONT 05257
2	6/4/98	REVISIONS PER REVIEW COMMENTS	DSM	MPY	802-442-8184
1	4/8/98	REVISIONS PER REVIEW COMMENTS	DSM	MPY	WRIGHT ENGINEERING, LTD.
			DSM	MPY	128 MERCHANTS ROW - P.O. BOX 176
			DRWN	CHKD	RUTLAND, VERMONT 05702-0176
					FAX 802-775-2311
					CIVIL ENGINEERS
					FAX 802-775-8915

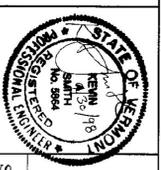

PROJECT NO. IM 091-1 (29)  
WATER & SEWER EXTENSION PROJECT  
TOWN OF GUILFORD  
TOWN OF BRATTLEBORO

SHEET TITLE: PUMP STATION DETAILS, WINDOW SCHEDULE AND DETAILS

STATE OF VERMONT  
AGENCY OF TRANSPORTATION  
SOUTHEAST VERMONT WELCOME CENTER  
GUILFORD, VERMONT



**RECORD DRAWING**

SHOWN PICTORALLY  
MAY NOT BE TO SCALE

THESE AS-BUILT OR RECORD DRAWINGS HAVE BEEN PREPARED, IN PART, ON THE BASIS OF INFORMATION COMPILED AND FURNISHED BY OTHERS. THE ENGINEER WILL NOT BE RESPONSIBLE FOR ANY ERRORS OR OMISSIONS WHICH HAVE BEEN INCORPORATED INTO THIS DOCUMENT AS A RESULT OF INFORMATION BY OTHERS.