


PLAN
SCALE: 1:500

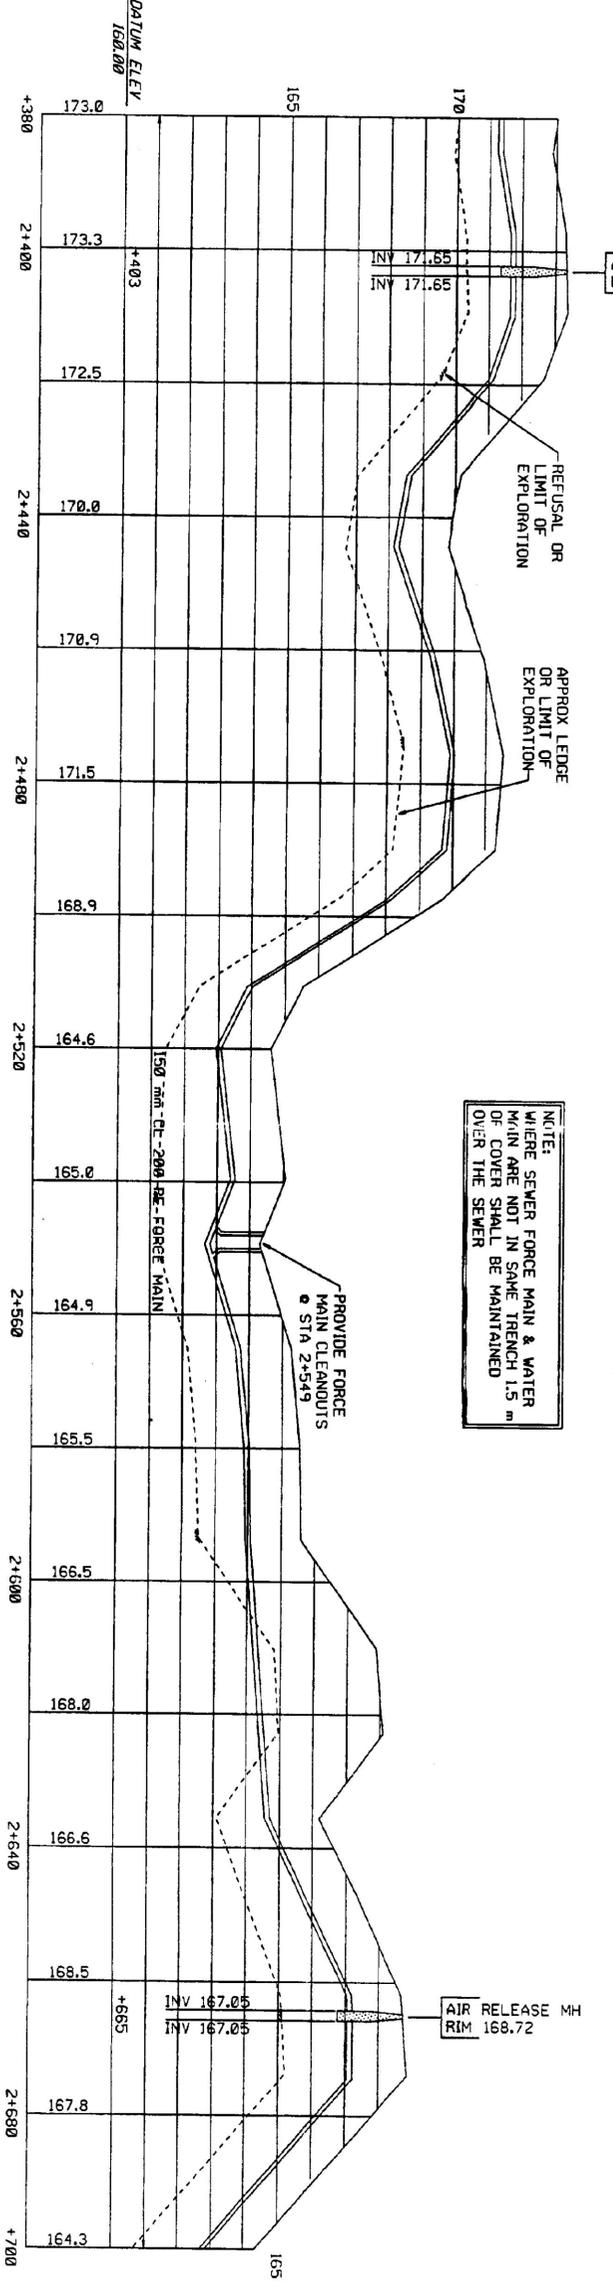

PROFILE
SCALE: 1:500 H
1:100 V

**FOR R.O.W.
USE ONLY**

091028 200 H.P.
/P/OP/310239/r-0239p8.l

NO.		DATE		REVISIONS	
<p>TIMOTHY D. SMITH & ASSOCIATES, P.C. OLD BALLBOUD STATION 88-148-041 WRIGHT ENGINEERING, LTD. 138 MERCHANTS ROW - PO BOX 174 05779-0144</p> <p>ARCHITECTS NORTH BARRINGTON, VERMONT 05647 FAX 802-486-6464</p> <p>CIVIL ENGINEERS RUTLAND, VERMONT 05701 FAX 802-778-0444</p>					
PROJECT NO: 99-1 (2)			DRAWN BY: JAC		
WATER & SEWER EXTENSION PROJECT			CHECKED BY: DSM		
TOWN OF BARRINGTON			DATE: 6-07-95		
SANITARY SEWER/WATER PLAN AND PROFILE			AGENCY OF TRANSPORTATION		
SOUTH EAST VERMONT WELCOME CENTER			STATE OF VERMONT		
R.O.W. SHEET 13 OF 15 SHEETS			SHEET 52 OF 54		