




PARTIAL FIRST FLOOR BELOW SLAB PIPING PLAN
SCALE 1/4" = 1'-0"

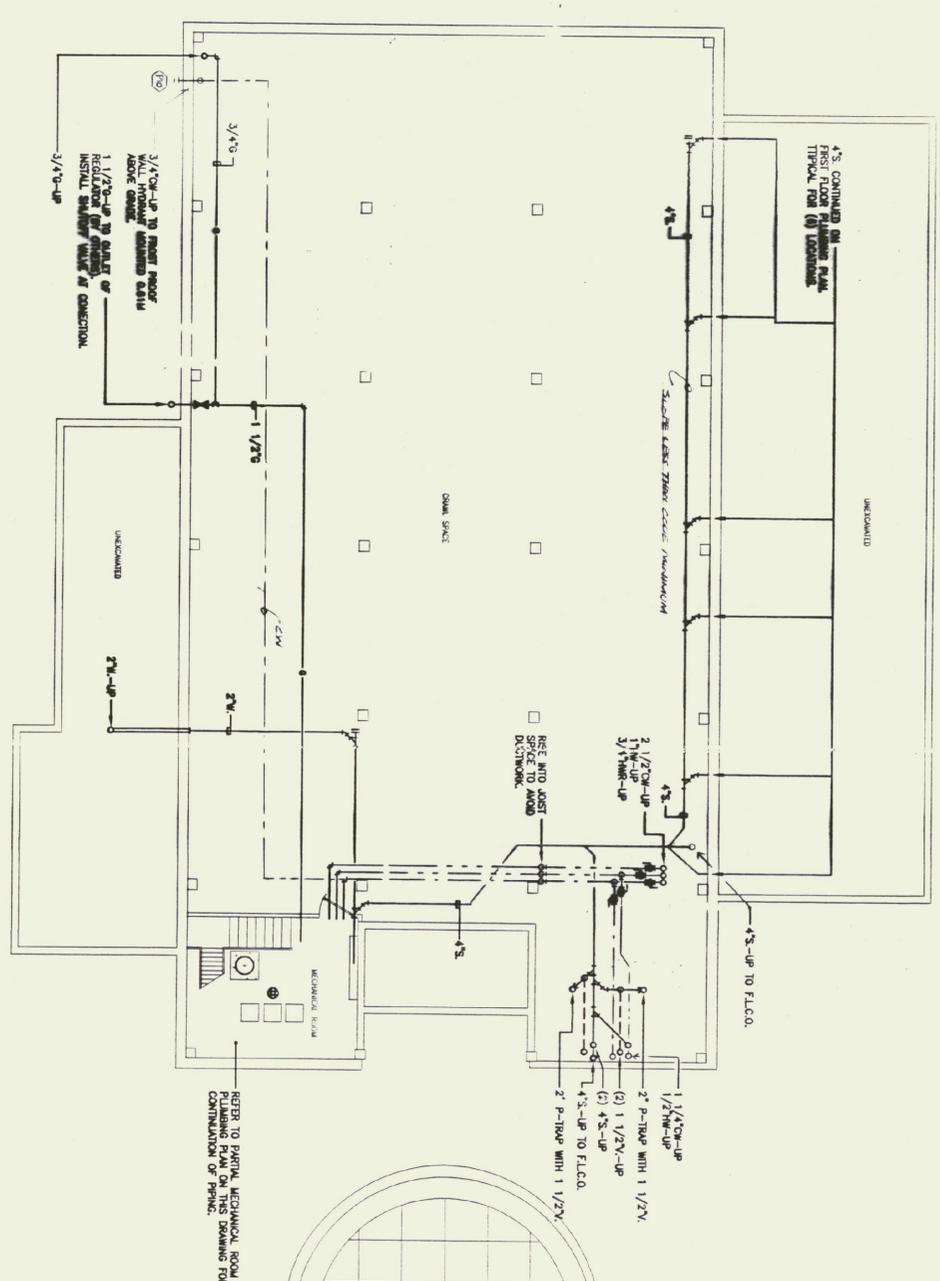

GRAVEL SPACE PIPING PLAN
SCALE 1/4" = 1'-0"

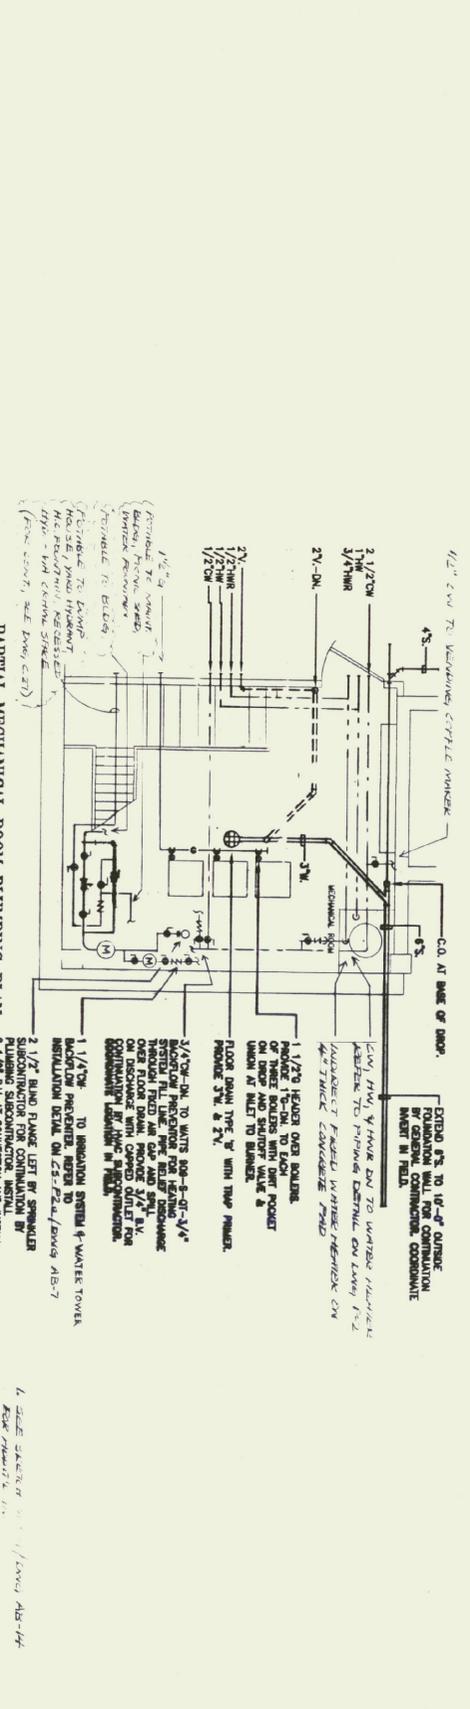

PARTIAL MECHANICAL ROOM PIPING PLAN
SCALE 1/4" = 1'-0"

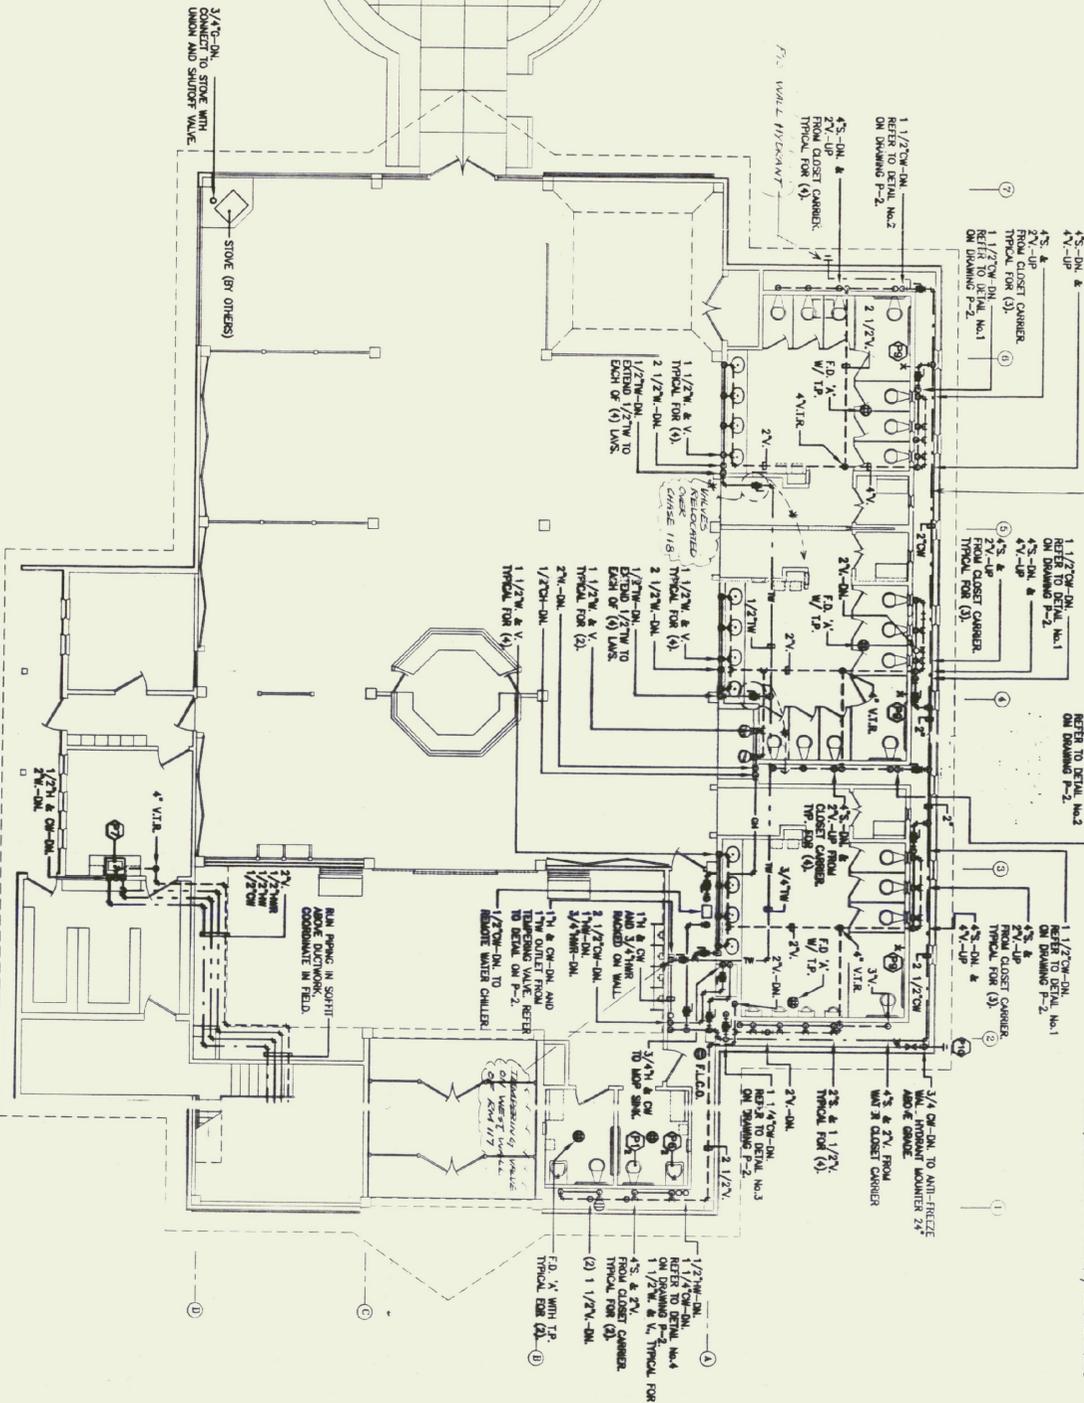

FIRST FLOOR PIPING PLAN
SCALE 1/4" = 1'-0"

RECORD
DRAWING

<p>TIMOTHY D. SMITH & ASSOCIATES, PC ARCHITECTS OLD BARRROAD STATION 802-442-8184</p>		<p>ROBERT W. HALL CONSULTING ENGINEERS, INC. 128 WASHINGTON ST. - 2ND FLOOR BURLINGTON, VERMONT 05401 TEL: 862-242-1111 FAX: 862-242-1111</p>	
<p>PROJECT NO. IM 091-1 (30) SOUTHEAST VERMONT WELCOME CENTER GUILFORD, VERMONT</p>		<p>STATE OF VERMONT AGENCY OF ADMINISTRATION DEPARTMENT OF BUILDINGS & GENERAL SERVICES</p>	
<p>DESIGN BY: MPL DRWN BY: MPL CHKD BY: RWH</p>		<p>DATE: REVISIONS: NO. DATE</p>	
<p>DRWN: CHKD</p>		<p>P-1</p>	

