




PANEL "A"		CIRCUIT BREAKER TYPE		MILB	
120/240V - 1Ø - SW - 5W	5W - 5W	W/AGED BUS	100AMP	MILB	W/AGED BUS
BREAKER CIRCUIT	COND. LOAD	W/AGED BUS	COND. W/AGED BUS	COND. W/AGED BUS	COND. W/AGED BUS
1-4	20	1	1/2	2-#12	2-#12
5	20	1	1/2	2-#12	2-#12
6	20	1	1/2	2-#12	2-#12
7	20	1	1/2	2-#12	2-#12
8	20	1	1/2	2-#12	2-#12
9-10	20	1	1/2	2-#12	2-#12
11	20	1	1/2	2-#12	2-#12
12	20	1	1/2	2-#12	2-#12
13	20	1	1/2	2-#12	2-#12
14	20	1	1/2	2-#12	2-#12
15	20	1	1/2	2-#12	2-#12
16	20	1	1/2	2-#12	2-#12
17	30	1	1/2	2-#12	2-#12
18	20	1	1/2	2-#12	2-#12
19-21	20	1	1/2	2-#12	2-#12
22-24	20	1	1/2	2-#12	2-#12

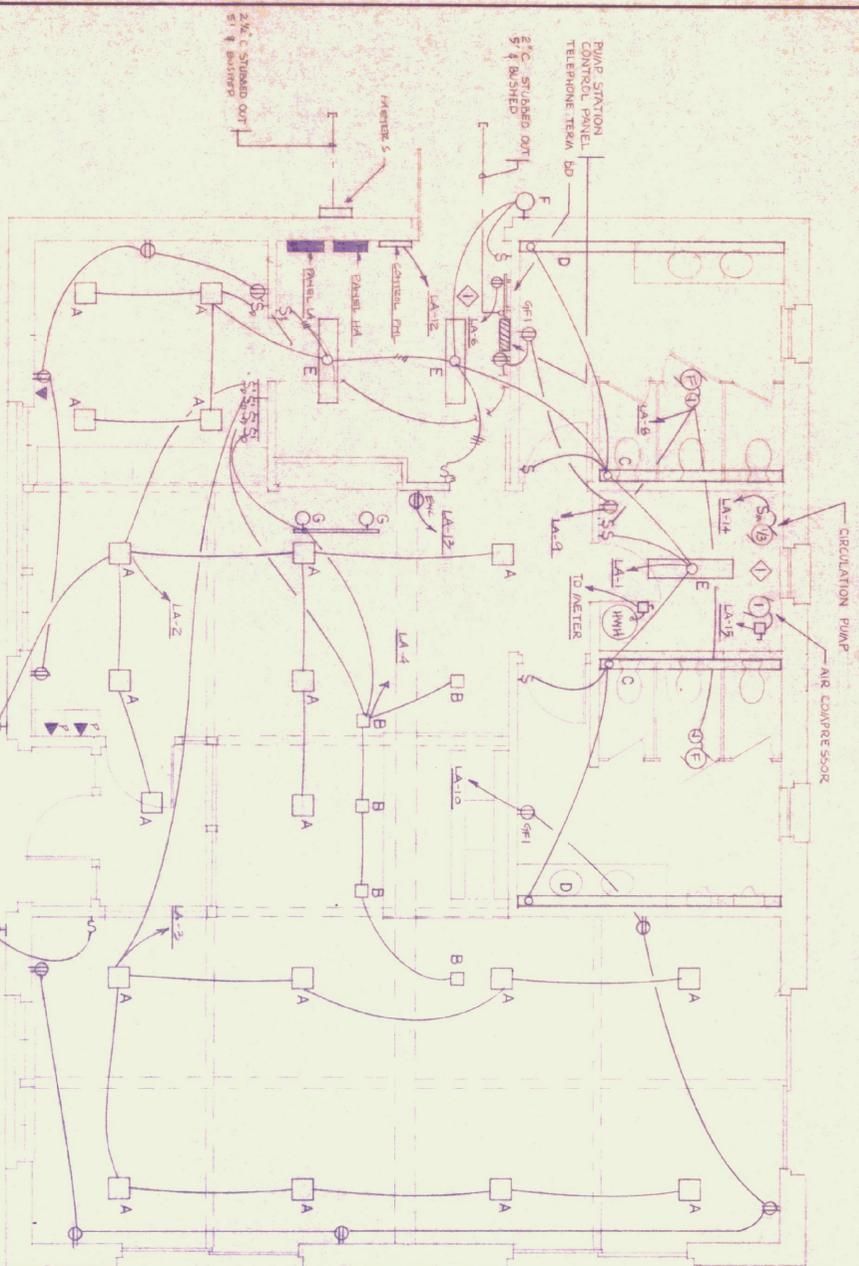


FLOOR PLAN - LIGHTING & POWER
SCALE: 1/4" = 1'-0"

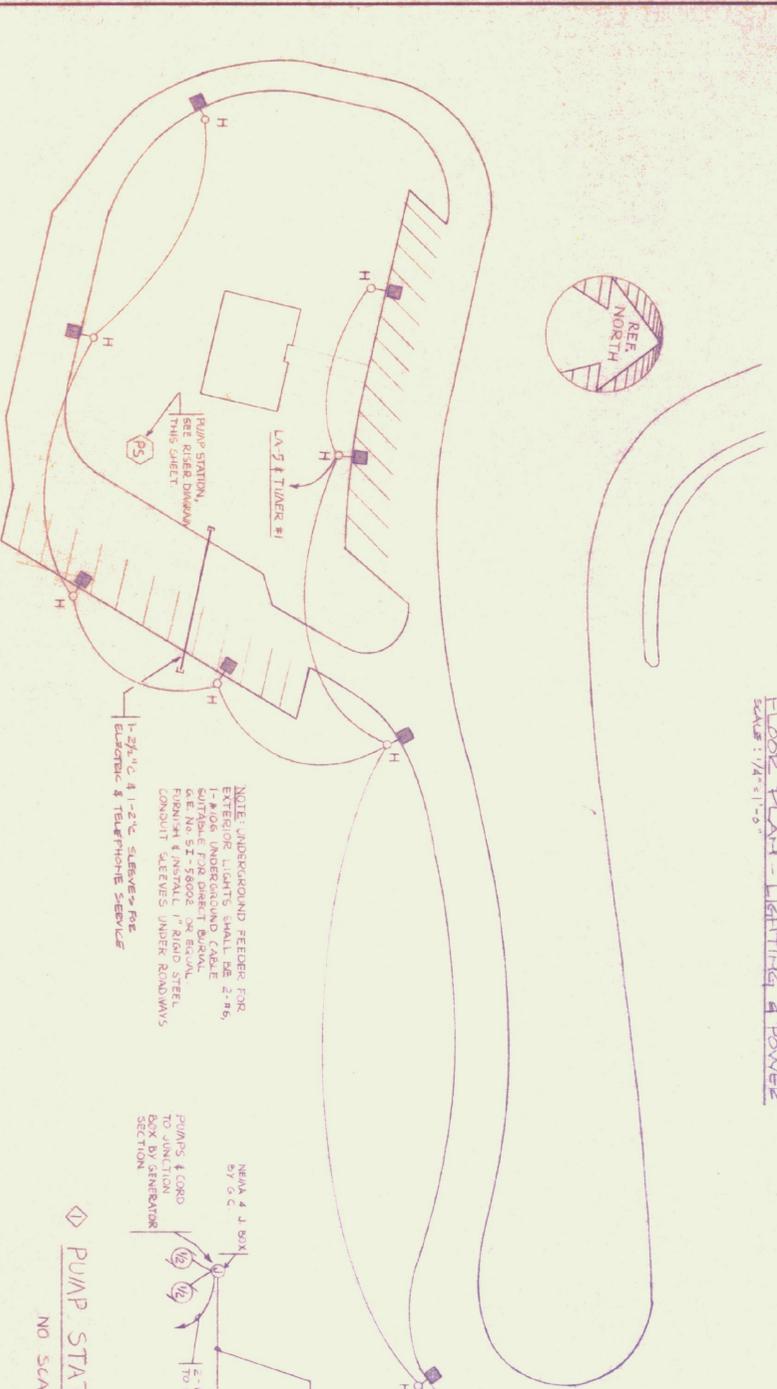


SITE PLAN
SCALE: 1/4" = 1'-0"

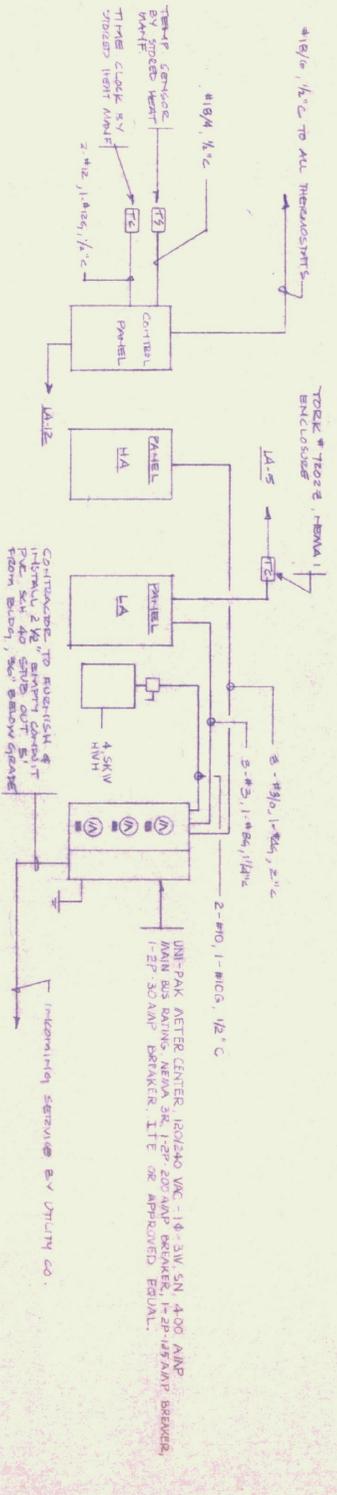

POWER RISER DIAGRAM
NO SCALE

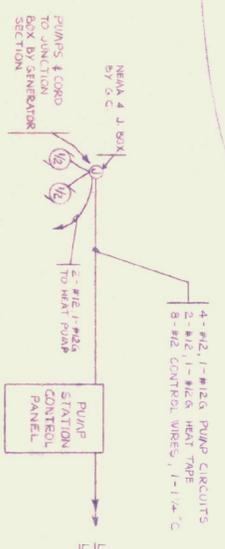

PUMP STATION RISER DIAGRAM
NO SCALE

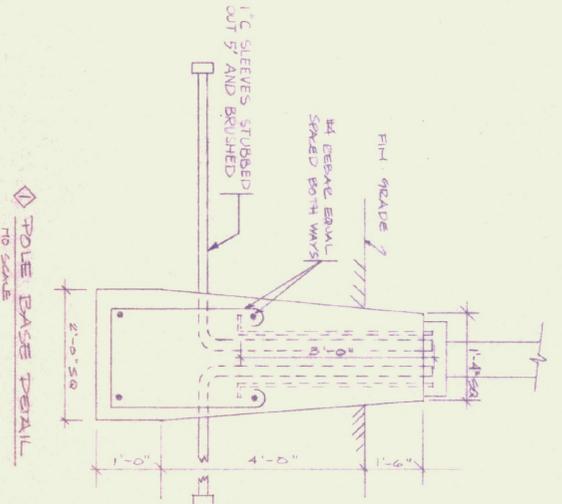

POLE BASE DETAIL
NO SCALE

- LEGEND**
- FLOOR/CEILING FINISH - LETTER DENOTES TYPE
 - WALL MOUNTED LETTER DENOTES TYPE
 - HORIZONTAL FINISH - WALL MOUNTED LETTER DENOTES TYPE
 - SINGLE POLE SWITCH - LEVITON #1221 (Hubbell 968), MOUNT TOP 44" A.F.F.
 - TRIP WAVE SWITCH - LEVITON #1223 (Hubbell 968), MOUNT TOP 44" A.F.F.
 - DIMMER SWITCH - LEVITON #1224 (Hubbell 968), MOUNT TOP 44" A.F.F.
 - DIMMER SWITCH - LEVITON #1225 (Hubbell 968), MOUNT TOP 44" A.F.F.
 - DIMMER SWITCH - LEVITON #1226 (Hubbell 968), MOUNT TOP 44" A.F.F.
 - DIMMER SWITCH - LEVITON #1300 (Hubbell 968), MOUNT TOP 44" A.F.F.

REVISIONS

NO.	DATE	REVISION
1	6-Nov-79	MISC. ADDITIONS & REVISIONS

ELECTRICAL

VERMONT WELCOME CENTER
FOR DIVISION OF STATE BUILDINGS
FAIRHAVEN VERMONT

WIEMANN-LAMPHERE, ARCHITECTS
340 SHELburnE STREET - BURLINGTON, VERMONT

REGISTERED ARCHITECT
JAMES A. WIEMANN
STATE OF VERMONT
No. 557

SCALE AS NOTED

DRAWING NO. **E.1**

DATE 20/11/79

DRAWN BY DMH

CHECKED BY DMH

PROJECT TPO.4