


HEATING - VENTILATING EQUIPMENT SCHEDULE

MARK	DESCRIPTION	MANUFACTURER & MODEL	CHARACTERISTICS	ELECTRICAL	REMARKS	NOTES
A	ELEC. STORAGE HEAT	AEG-TELEFUNKEN - WSP-526-UL	5.0 kw	240 V. 14.60 Hz	DESIGN BASED ON 8' H. STORAGE CHARGE	
B	"	"	4.0 kw	"	"	
C	"	"	3.0 kw	"	"	
D	"	"	2.0 kw	"	"	
E	ELECTRIC BASEBOARD	EMERSON-CHEMMANIX - BE-H1342	32" L. 750 W. - 2900 Btu	"	"	WITH SEE CONT. LIST
F	CEILING EXHAUST FAN	CARVER-WUER CORP. - EC-15	88 CFM @ 10 ESP 1.6 BMS	120 V. 14.60 Hz	CON. DUCT FROM FAN TO AIR SHAFT.	

Panel "HA" CIRCUIT BREAKER TYPE FUSES		200 AMP F.C.B.	
No.	Rating	WIRE SIZE	WIRE TYPE
1-7	2	30	1/2"
8-10	2	30	1/2"

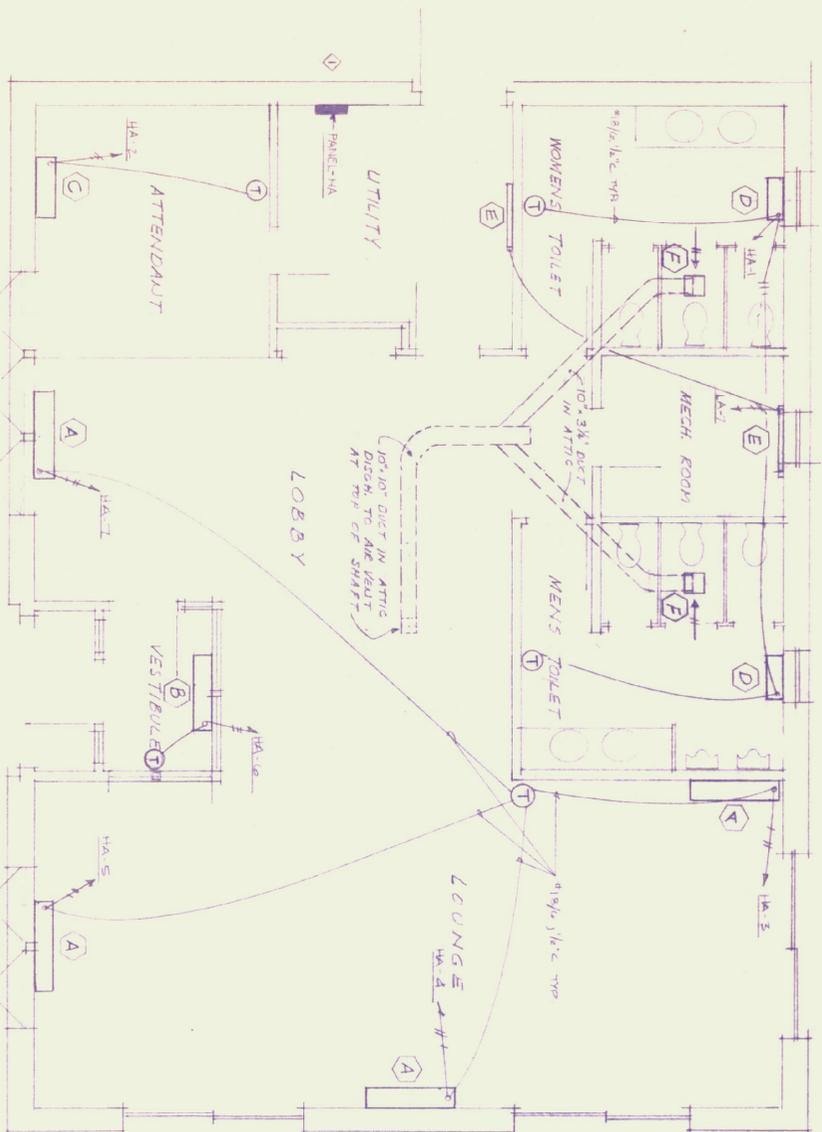

FLOOR PLAN
SCALE 1/4" = 1'-0"

NO.	DATE	REVISION
1	MAY 11, 1954	DEVELOPED SAILER, HA

ESTHETIC HEAT

REDWANT WELCOME CENTER
FOR DIVISION OF STATE BUILDINGS
FAIRHAVEN
VERMONT

WIEMANN - LAMPHERE, ARCHITECTS
346 SHELburne STREET - BURLINGTON, VERMONT

SCALE: AS SHOWN
DATE: 5/11/54
DRAWN BY: SWE/SMH
CHECKED BY: JSMH
PROJECT:

DRAWING NO. **E-2**

