
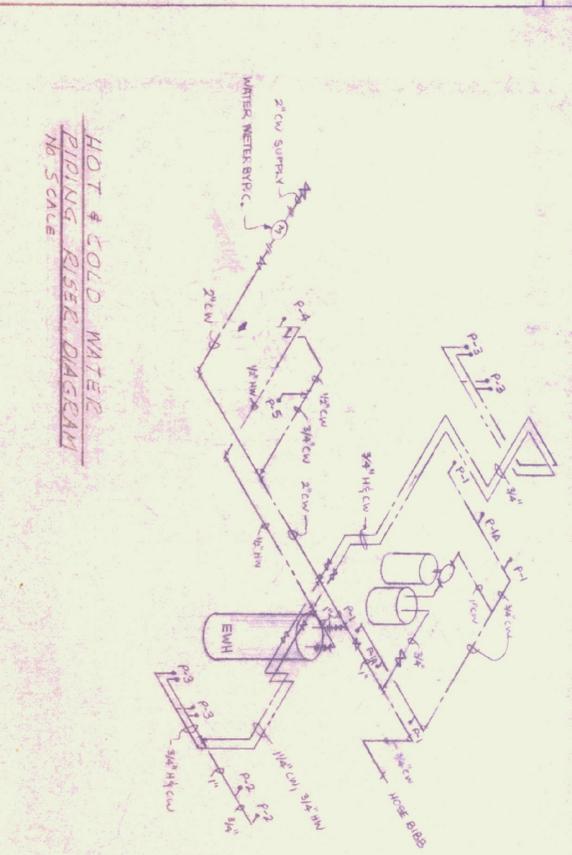
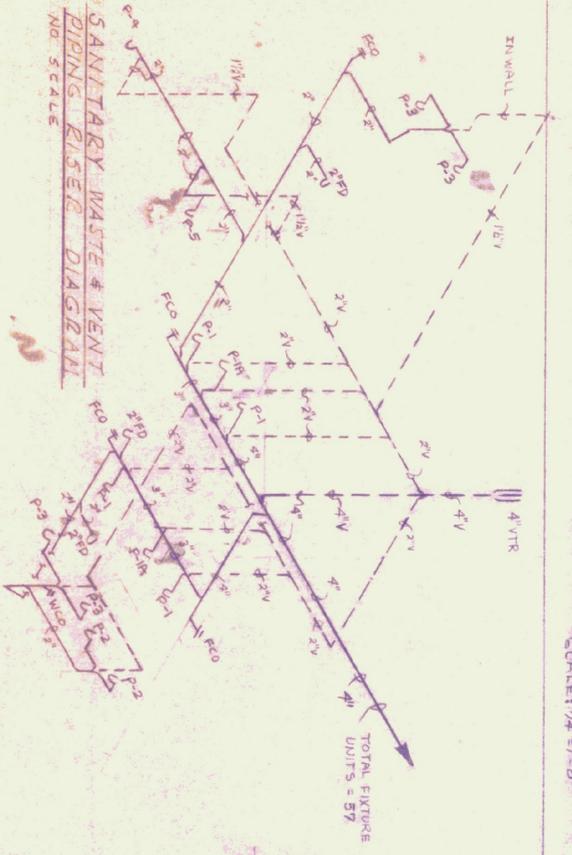
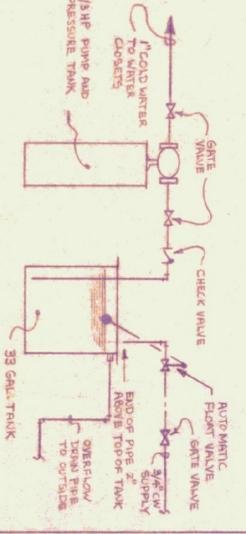
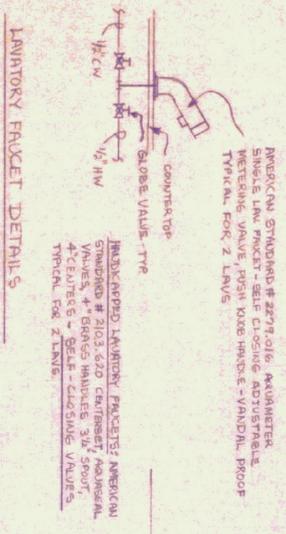
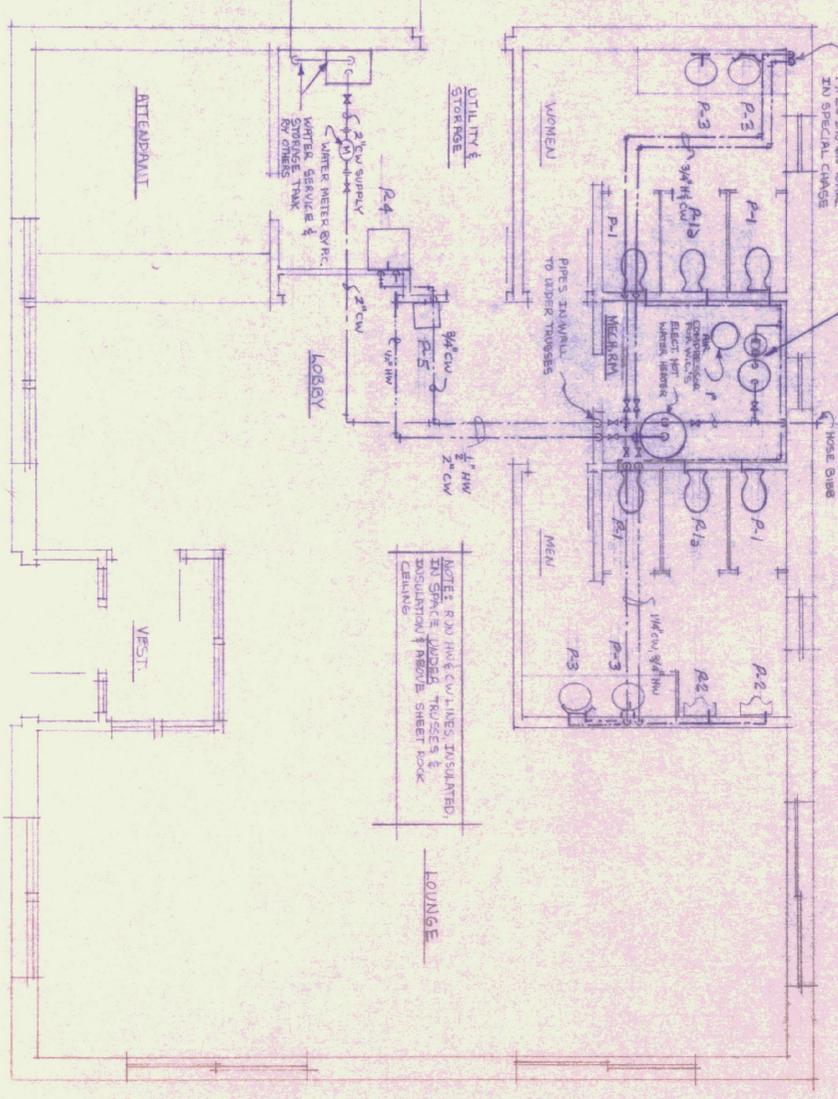


PLUMBING FIXTURE SCHEDULE

MARK	DESCRIPTION	MANUFACTURER & MODEL	CONNECTIONS	REMARKS	NOTES
P-1	WATER CLOSET FLOOR MOUNT	WATERMATIC, LOW FLUSH TOILET - 2.0 GPM, VITREOUS CHINA, MODEL LE-202-2	1/2" W x 1/2" V		③
P-1A	WATER CLOSET HANGING	WATERMATIC, LOW FLUSH TOILET - 2.0 GPM, VITREOUS CHINA, MODEL LE-202-1	1/2" W x 1/2" V	SHUT TO BE EQUIPPED WITH W/TEMPERATURE SENSITIVE VALVE	③
P-2	URINAL, WALL MOUNTED	WATERMATIC, 6000, 0.6 GPM, VITREOUS CHINA, MODEL LE-201-1	1/2" W x 1/2" V	REMOVE COMPARTIBLE CHAIR	① ②
P-3	LABATORY COUNTERTOP	WATERMATIC, 6000, 0.6 GPM, VITREOUS CHINA, MODEL LE-201-1	1/2" W x 1/2" V	SET-CLASING HANDLE, 3/4" CHAIR	①
P-4	MOP RECEPTOR 24" X 24" X 6"	WATERMATIC, 6000, 0.6 GPM, VITREOUS CHINA, MODEL LE-201-1	1/2" W x 1/2" V	RECESSED IN FLOOR, 3.5 GPM FLOW RESTRICTOR	
P-5	ELECTRIC WATER COOLER	ELKAY, EHT-8, WALL HUNG	1/2" W x 1/2" V	FOR MULTICAPTURE & AGE-WITH/TEMPERATURE SENSITIVE VALVE, PRESS TO 6" AIR	
EMH	ELECTRIC WATER HEATER	A.O. SMITH, REC-82, 80 GAL, TO MEET ASHRAE 90.2G STANDARD FOR ENERGY EFFICIENCY, 2000 WATT, 240V, 15A, 1/2" NPT	1" W x 1" V	W/TEMPERATURE SENSITIVE VALVE, PRESS TO 6" AIR	
HOSE	HOSE BIBS	WOODBORD FREE BELLETS W/MT-COMMUNICATION MODEL 85 W/WR, BISHNER	3/4" W x 1" V	TO FIT WALL THICKNESS	

LEGEND

—	COLD WATER PIPING
—	HOT WATER PIPING
—	GATE VALVE
—	SHUTLIDE - UNDER SLAB
—	UNION
—	VENT THRU ROOF
—	FLOOR DRAIN
—	FLOOR CLEAN OUT
—	PLUMBING CONTRACTOR REMOVE FINISH FLOOR
—	VENT PIPING
—	WALL CLEAN OUT

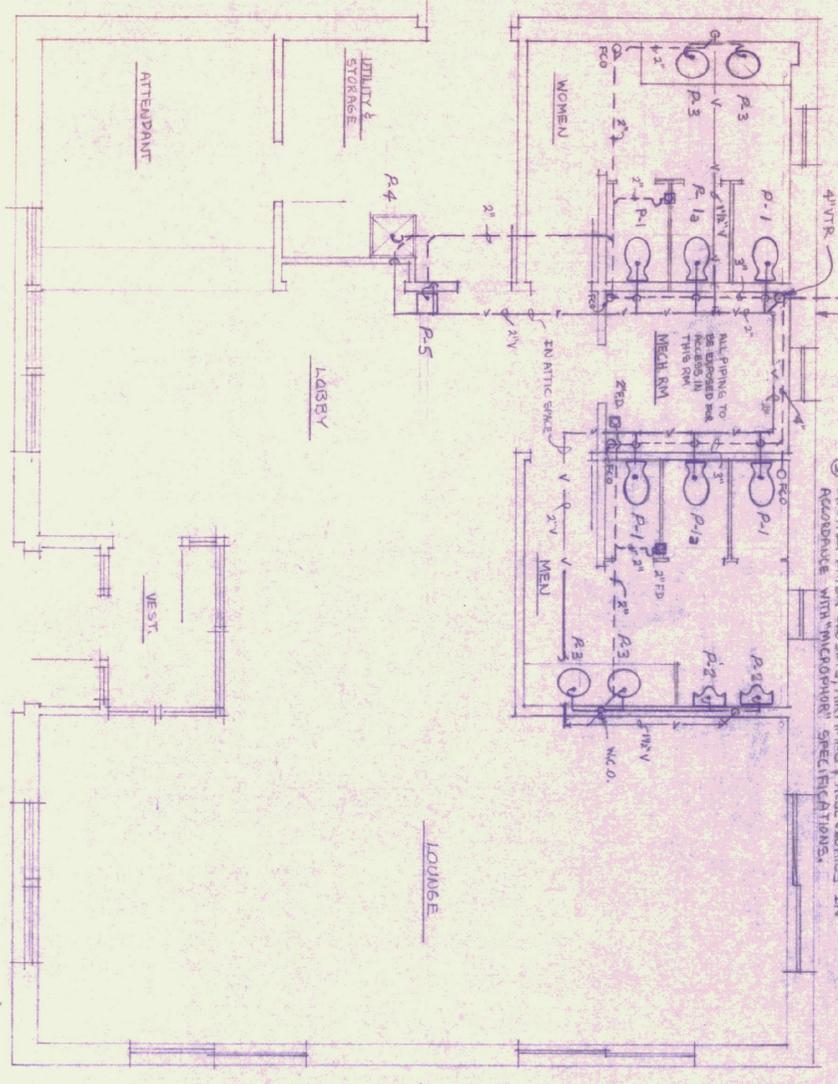

VERMONT WELCOME CENTER
 FOR DIVISION OF STATE BUILDINGS
 FEAR HAVEN, VERMONT

WIEMANN - LAMPHERE, ARCHITECTS
 346 SHELBURNE STREET - BURLINGTON, VERMONT

PLUMBING SYSTEM

NO.	DATE	REVISION
Δ	26X77	REVISED PLUMBING SYSTEM

SCALE AS NOTED
 DATE 3/23/72
 DRAWN BY JNF
 CHECKED BY GWR
 PROJECT 7824

DRAWING NO. **P1**