



LEGEND

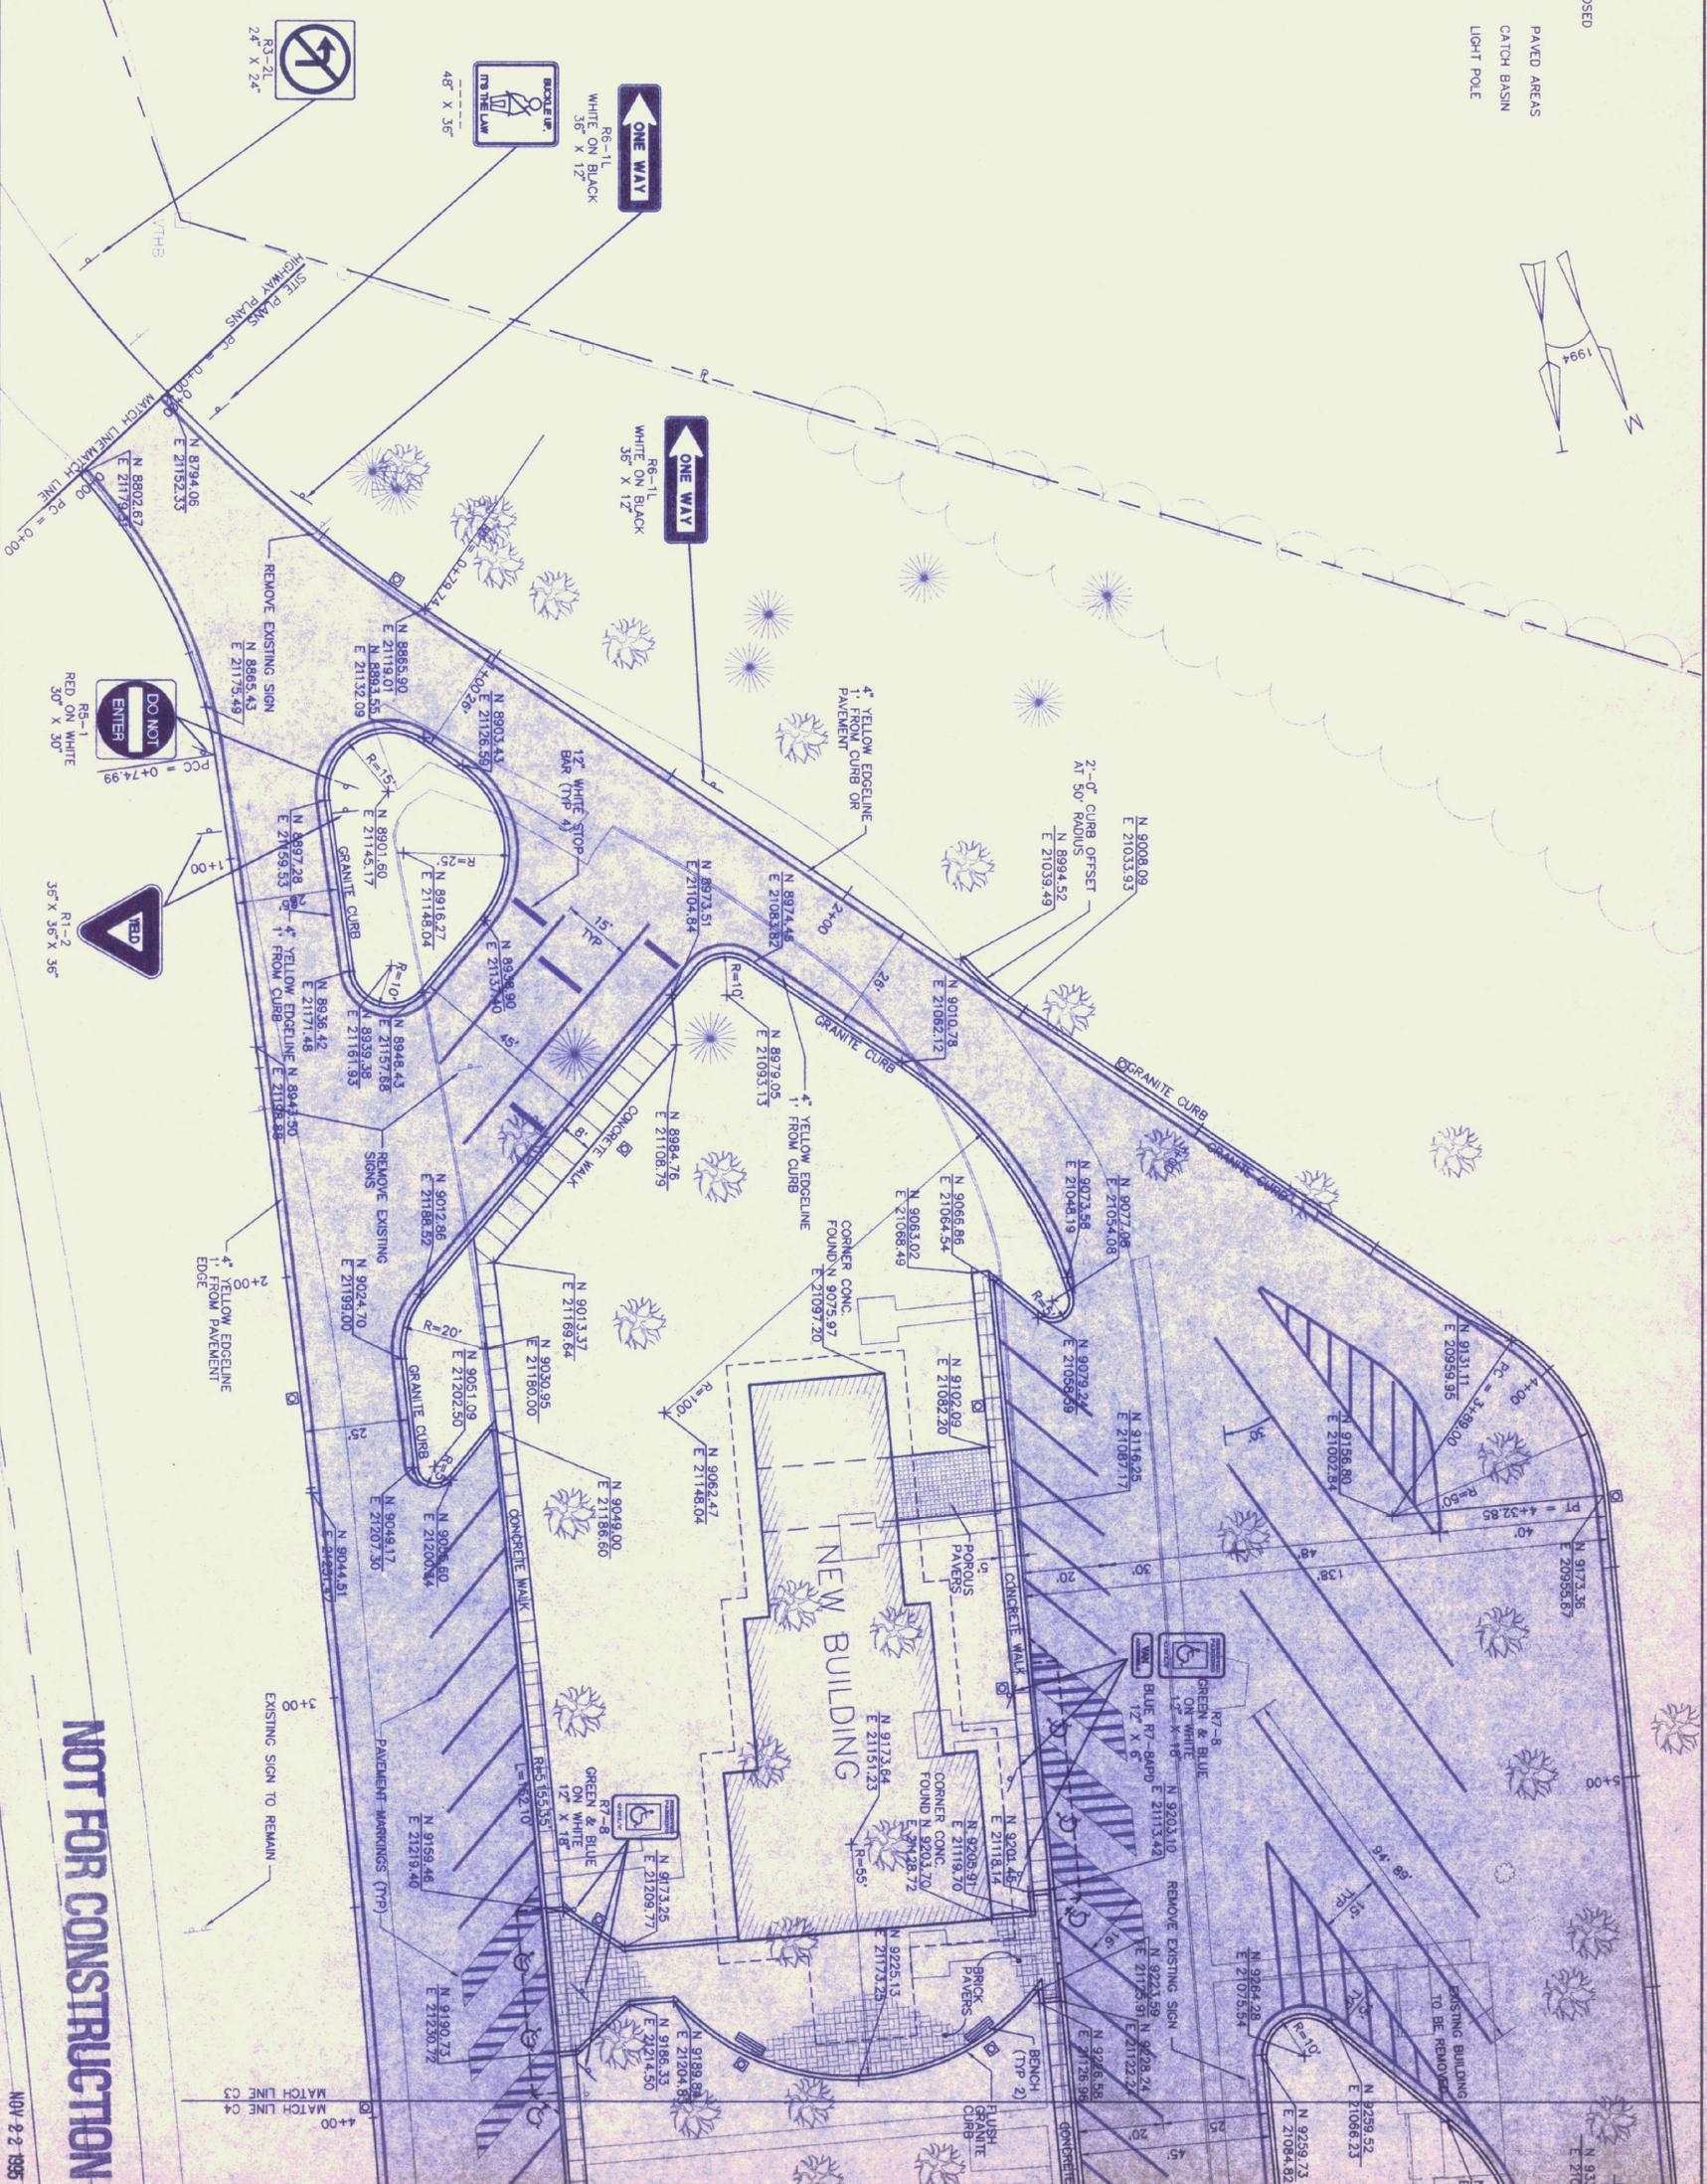

NOTES:

1. REFER TO LANDSCAPE PLAN FOR TREES TO BE PROTECTED AND KEPT FOR FINAL LANDSCAPING.
2. REFER TO ELECTRICAL PLANS FOR NEW LIGHT FIXTURES AND ELECTRICAL SITEWORK. EXISTING LIGHT FIXTURES TO BE REMOVED.
3. EXISTING BITUMINOUS PAVEMENT AND CURBS TO BE REMOVED.
4. EXISTING CONCRETE WALKS AND PICNIC PADS TO BE REMOVED.
5. REFER TO GRADING, DRAINAGE AND EROSION CONTROL PLANS FOR REMOVAL OF EXISTING DRAINAGE AND LAYOUT OF NEW DRAINAGE SYSTEM.
6. CONTACT "DIG-SAFE" PRIOR TO CONSTRUCTION TO LOCATE EXISTING BURIED TELEPHONE AND ELECTRIC LINES.

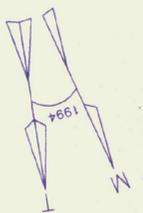

NOT FOR CONSTRUCTION

N.B.F.
Nimtz & Berryhill Figiel
ARCHITECTS P.C.
24 1/2 Cedar Street, Rutland, Vermont 05701

Steven J. Banik, P.E.
STRUCTURAL ENGINEER
Cuttingerville, Vermont 05798

Dubois Sking Inc.
Highway Design
Site Engineering
Mechanical and Electrical Engineers

SOUTHBOUND WHITE RIVER JUNCTION TRAVEL AND INFORMATION CENTER HARTFORD, VERMONT

LAYOUT, MARKING and SIGNAGE PLAN A

Prof. No. R12688
Dwg No. —
Drawn By: KRK
Checked By: JHB
Proj. Eng. —
Revised —
DATE: NOV/1995
ISSUED FOR: PRELIMINARY
DRAWING NUMBER: **C3**

NOV-22-1995