

REVISIONS	BY

COPYRIGHT © 2001  
CHAMPLAIN CONSULTING ENGINEERS  
ALL RIGHTS RESERVED


**CHAMPLAIN CONSULTING ENGINEERS**  
85 PRIM ROAD, P.O. BOX 453  
COLCHESTER, VERMONT 05446  
(802) 863-8060  
(802) 864-1878 FAX



**INTERSTATE 89 NORTHBOUND  
WILLISTON INFORMATION CENTER  
UTILITY PLAN**  
PROJECT # IM-BIDG(4)  
WILLISTON VERMONT


DRAWN  
CCE  
CHECKED  
PD  
SCALE  
1" = 40'  
DATE  
01/16/01  
JOB NO.  
93114  
SHEET

**C3nb**  
OF 22 SHEETS

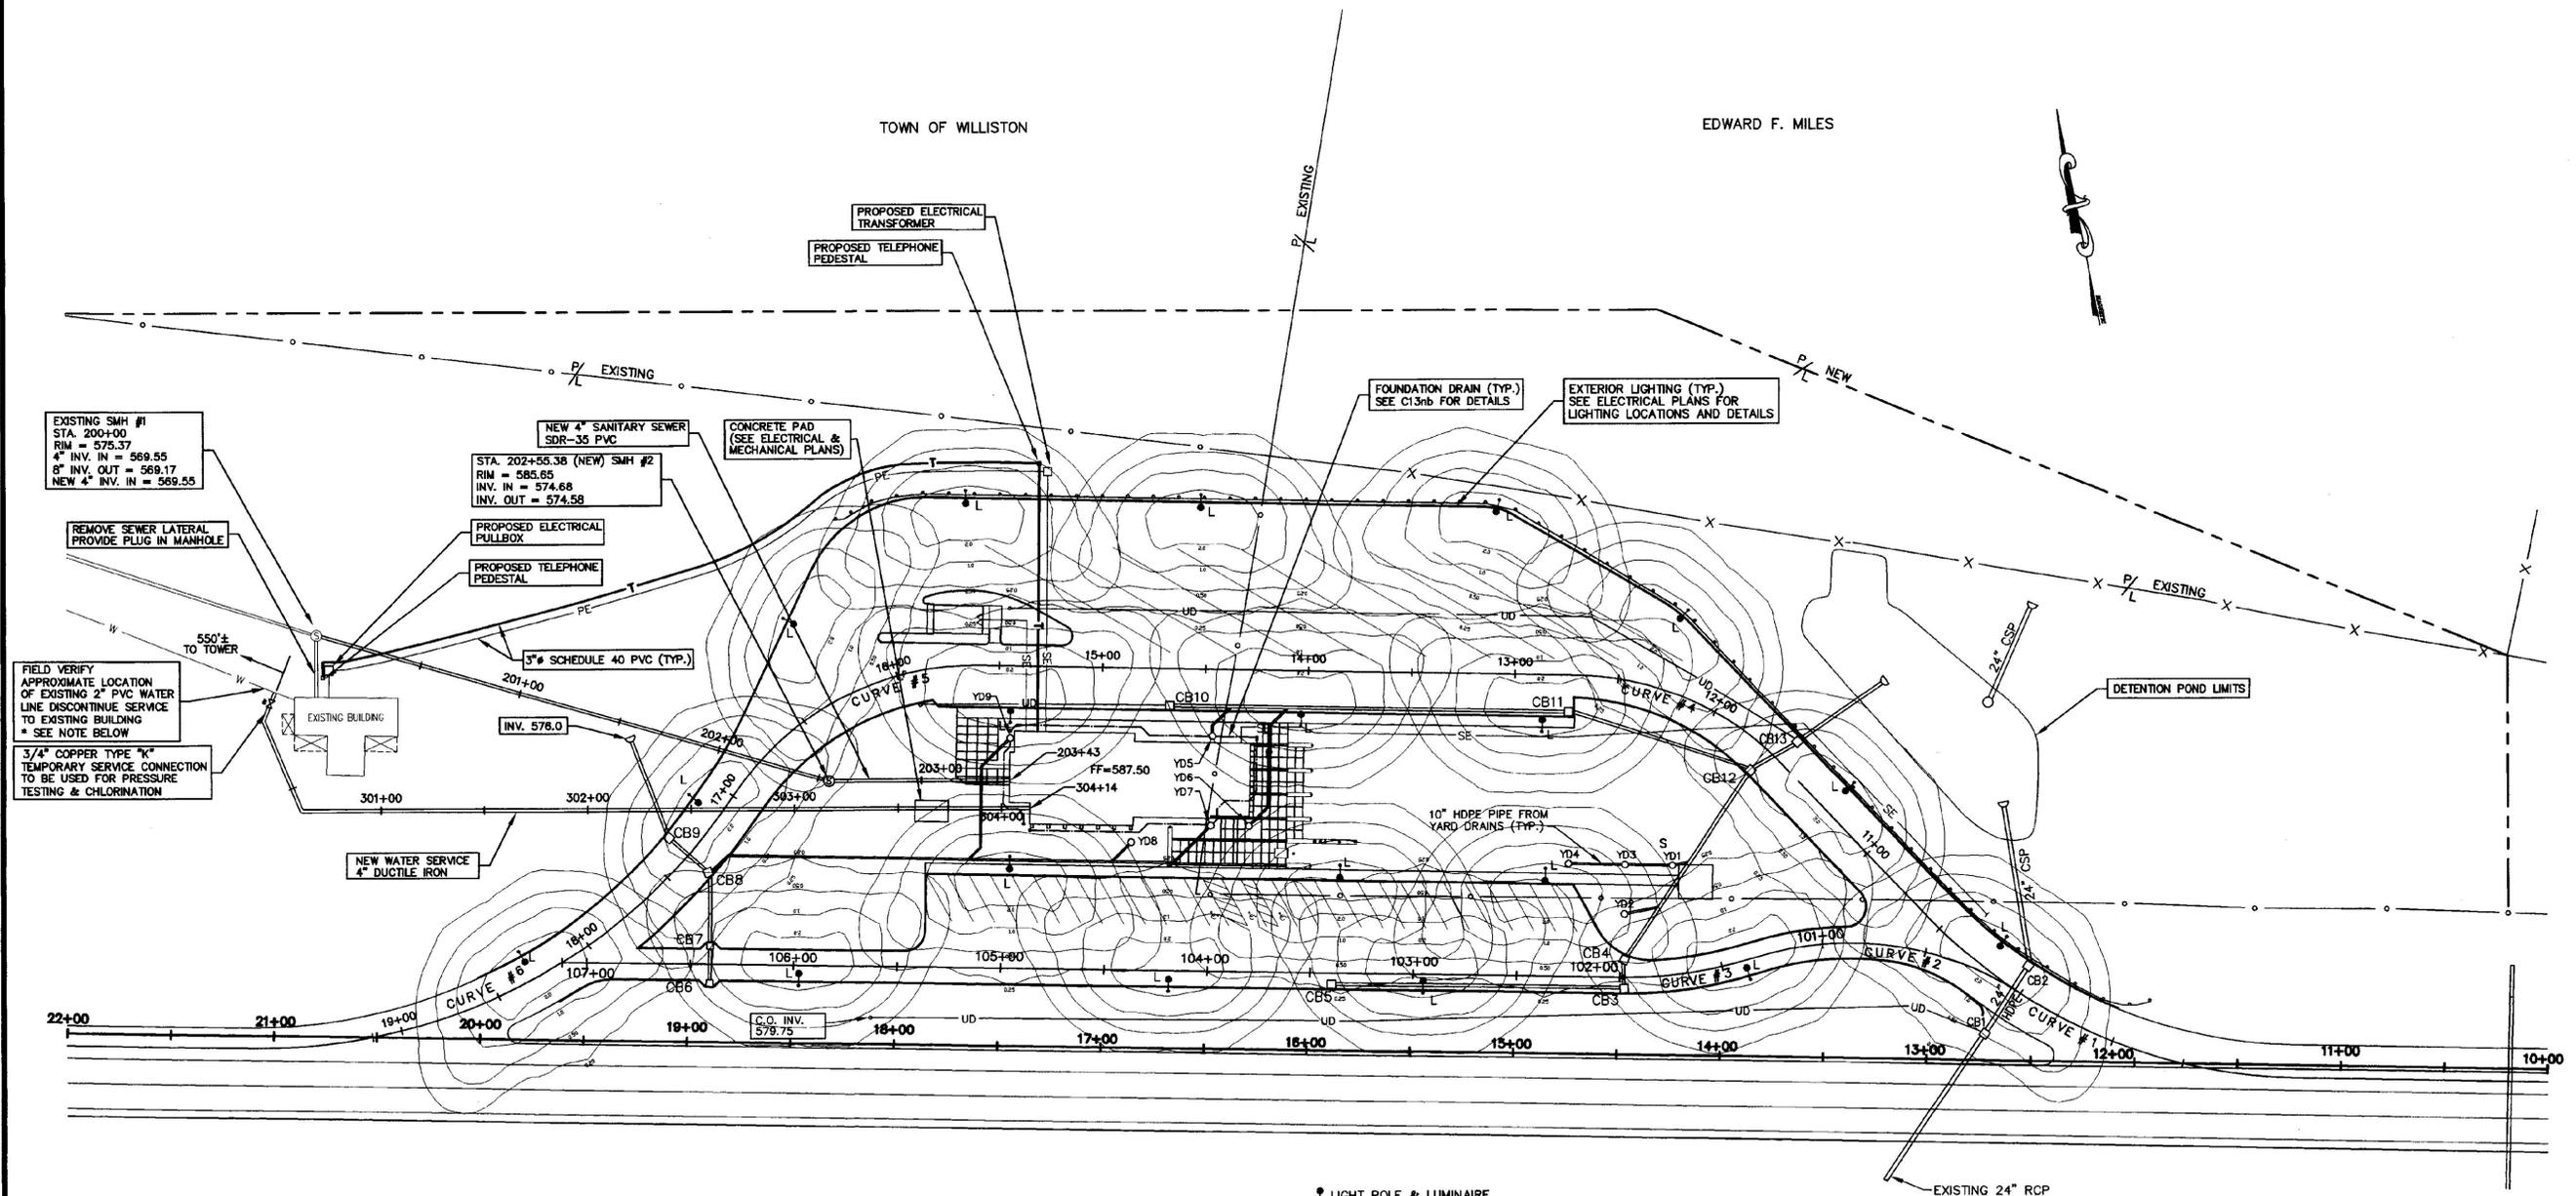

FOR ELECTRICAL INSTALLATION NOTES  
SEE DRAWING E1nb PROJECT NO. 2397.02  
BY HALLAM ASSOCIATES

 **SITE PLAN**  
SCALE 1" = 40'



**PIPING NOTES:**  
ALL NEW STORM PIPING TO BE 18" HDPE UNLESS NOTED OTHERWISE  
ALL NEW FOUNDATION DRAIN PIPING TO BE 6" SDR 35 PVC  
ALL NEW WATER PIPING TO BE 4" DUCTILE IRON  
ALL NEW SANITARY SEWER PIPING TO BE 4" SDR 35 PVC  
  
ALL EXISTING DRAINAGE PIPING NOT TO BE REUSED SHALL BE REMOVED

AT PROJECT START UP CONTRACTOR SHALL LOCATE EXISTING 2" WATER LINE, MAKE NEW 2" CONNECTION W/ APPROPRIATE VALVING AND DETERMINE INITIAL PRESSURE & FLOW AT POINT OF CONNECTION. SUBMIT RESULTS TO CIVIL AND MECHANICAL ENGINEER. AFTER NEW WATER SERVICE HAS BEEN ESTABLISHED TO WITHIN 10' OF BUILDING LOCATION, CONDUCT FLOW TEST AT TERMINATION WITH SIMULTANEOUS CHECK OF RESIDUAL PRESSURE AT ORIGINAL CONNECTION TO EXISTING LINE.

\* PROJECT ADD ALTERNATE TESTING RESULTS MAY INDICATE THAT EXISTING 2" WATER SERVICE BE REPLACED BY 4" DUCTILE IRON. UNIT PRICE SHALL INCLUDE TAPPING SLEEVE AND VALVE AT EXISTING CONNECTION BOX, ALL REQUIRED APPURTENANCES, RESTORATION AND TESTING.

CCE/MAC TheC3b 4/31/01 10:51:14 AM D:\Projects\2001-01-16 05446