



CRAWL SPACE AND MAIN LEVEL SANITARY RISER
NO SCALE

NOTE:
FOR INDIVIDUAL FIXTURE CONNECTION SIZES, REFER TO SCHEDULE ON DRAWING P-1sb

NOTES:
1. FOR CONTINUATION SEE ATTIC PLAN THIS DRAWING.

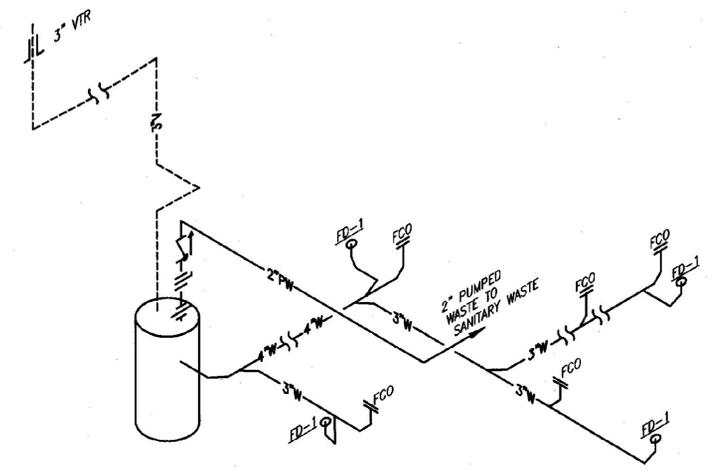

CRAWL SPACE WASTE COLLECTION SYSTEM RISER
NO SCALE

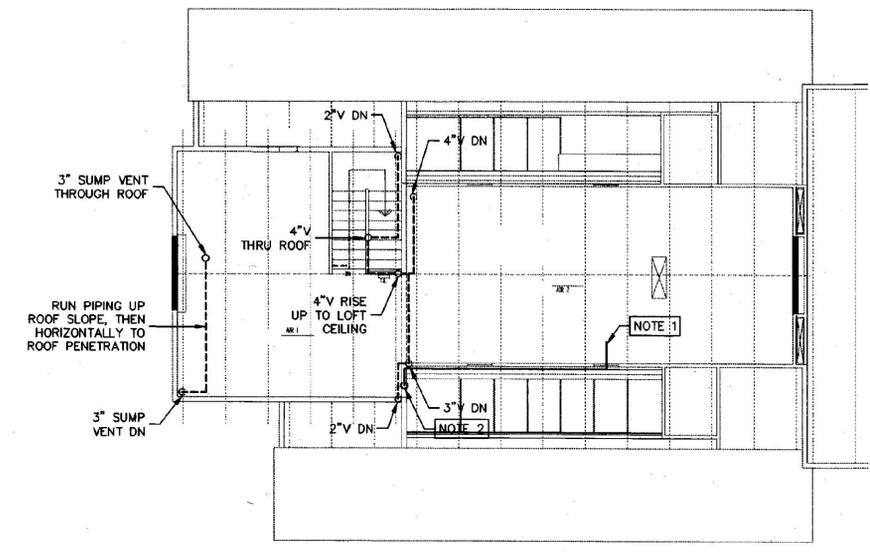

LOFT PLUMBING PLAN
SCALE: 1/8"=1'-0"

NOTES:
1. PROVIDE FULL SIZE CONDENSATE DRAIN LINE FROM AIR HANDLING UNIT DRAIN PAN. ROUTE PIPING ALONG WALL NEXT TO DUCTWORK. SLOPE PIPING IN DIRECTION OF FLOW.
2. ROUTE PIPING DOWN THROUGH FLOOR AND TERMINATE OPEN ENDED ABOVE RECESSED FLOOR AREA 12" ± ABOVE FLOOR.

G:\Drawings\10215000\North_Bound\p-4nb.dwg Tuesday, January 16, 2001 1:22:42 pm jdl

No.	DATE	REVISION

DUNCAN • WISNIEWSKI ARCHITECTURE
255 SOUTH CHAMPLAIN STREET, BURLINGTON, VERMONT 05401 (802) 864-9883

Hallam Associates
80 Barrill Street, Suite 800
Burlington, Vermont 05401
(802) 658-4891

WILLISTON INFORMATION CENTER
189 SOUTHBOUND
STATE PROJECT # IM-BLDG (4)

SANITARY RISERS AND DETAILS
AND LOFT PLUMBING PLAN

DRAWN: J.LAMOTHE	PROJ.No: 10215
CHECKED: M.COOK	DATE: JAN 16, 2001

P-4nb