
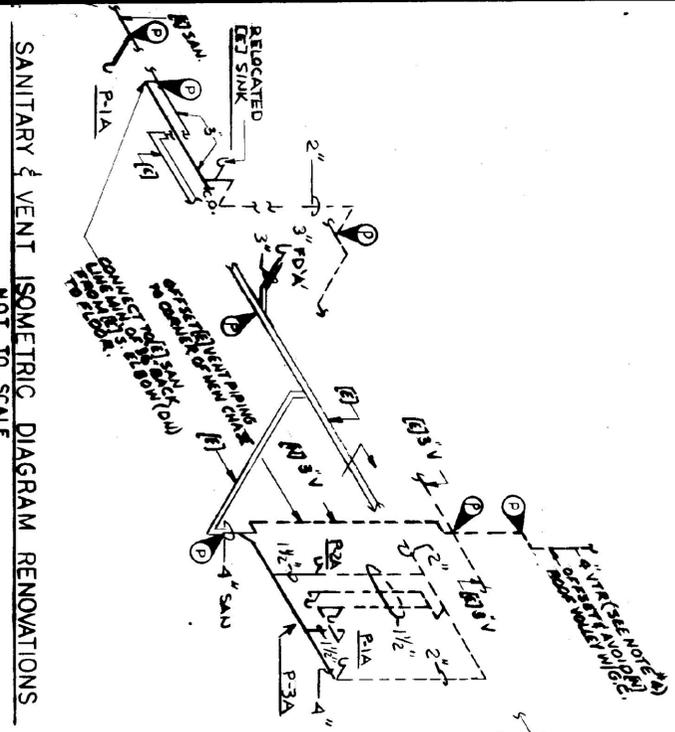


PLUMBING-EXISTING FLOOR PLAN-DEMOLITION
SCALE: 1/4"=1'-0"


GENERAL NOTE:
PLUMBING CONTRACTOR TO REMOVE ALL EXISTING FAUCETS FLUSH VALVES ETC. WHICH ARE NOT TO BE REPLACED WITH NEW. REPLACE ALL WASHERS WITH NEW.

- NOTES:
1. THE UNDERGROUND SANITARY SYSTEM PIPING IS ASSUMED TO BE AS SHOWN ON THE GENERAL DEMOLITION PLAN. THE CONTRACTOR SHALL FIELD VERIFY ITS EXISTENCE PRIOR TO THE GENERAL CONTRACTOR BREAKING UP THE FLOOR.
 2. COORDINATE ALL WORK WITH EXISTING CONDITIONS & (R) WORK BY OTHER TRADES.
 3. RELOCATE (R) SINK W/ ALL (R) HOT & COLD WATER PIPING W/ EXPOSURE. REMOVE (R) SINK WITH (R) HOT & COLD WATER PIPING. REMOVE (R) SINK WITH (R) HOT & COLD WATER PIPING. REMOVE (R) SINK WITH (R) HOT & COLD WATER PIPING. REMOVE (R) SINK WITH (R) HOT & COLD WATER PIPING.
 4. EXTEND (R) & VENT UP THRU NEW ROOF STRUCTURE OFF SET AS NEEDED TO AVOID ROOF VALVE. THIS CONTRACTOR TO FURNISH NEW TO A CORNER ROOF SLEAVE TO MATCHING SUB CONTRACTOR.
 5. FURNISH & INSTALL (R) VACUUM BREAKERS ON (R) HOSE BIBBS (TYPE 3).
 6. SEE DWG P-3.0 FOR LEGEND, FIXTURE SCHEDULE & DETAILS.

PLUMBING-FLOOR PLAN-RENOVATIONS
SCALE: 1/4"=1'-0"

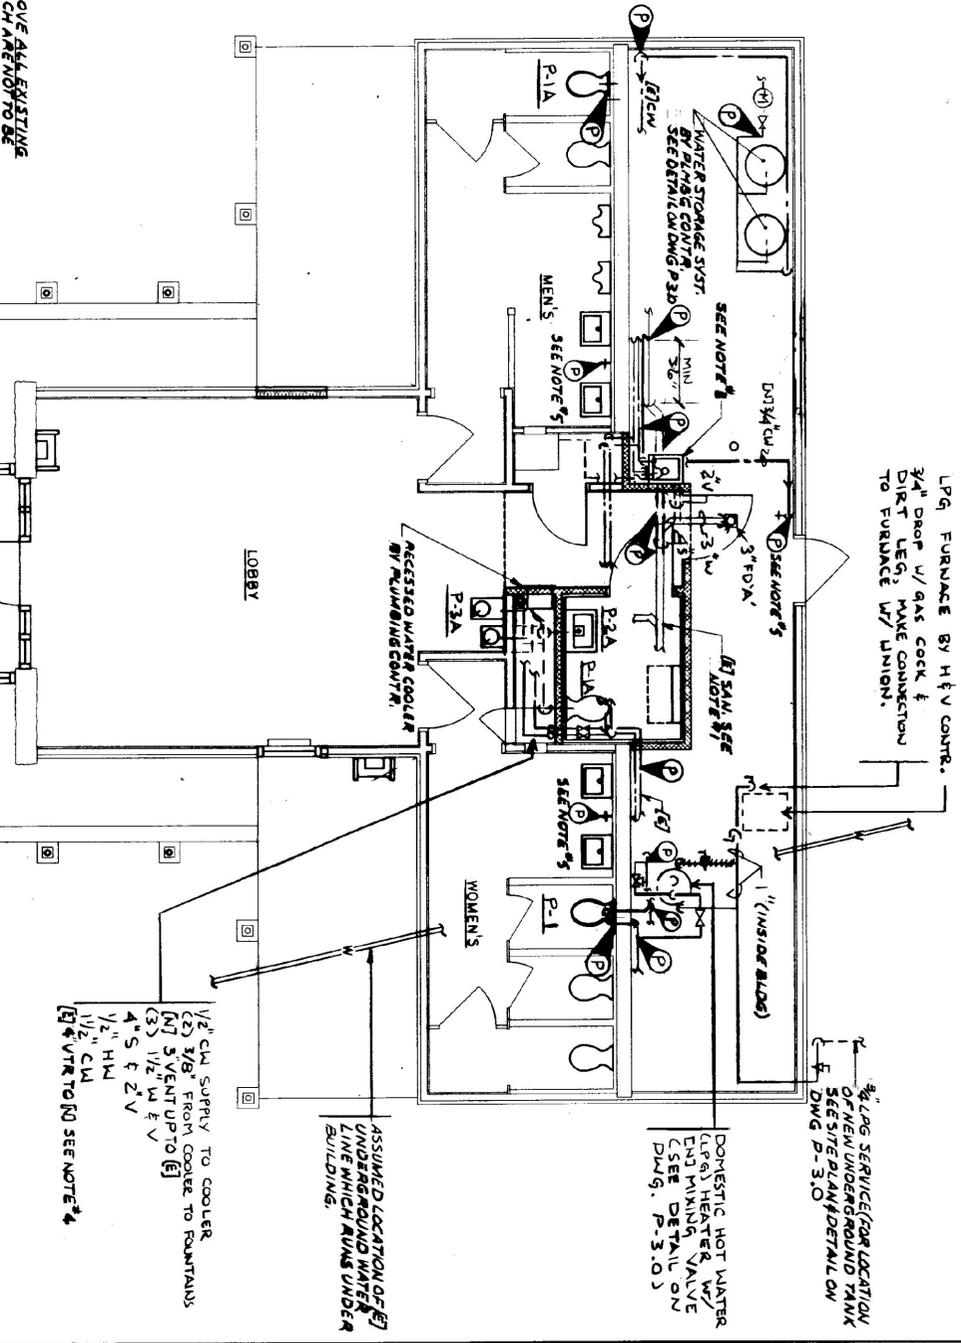

SANITARY & VENT ISOMETRIC DIAGRAM RENOVATIONS
NOT TO SCALE

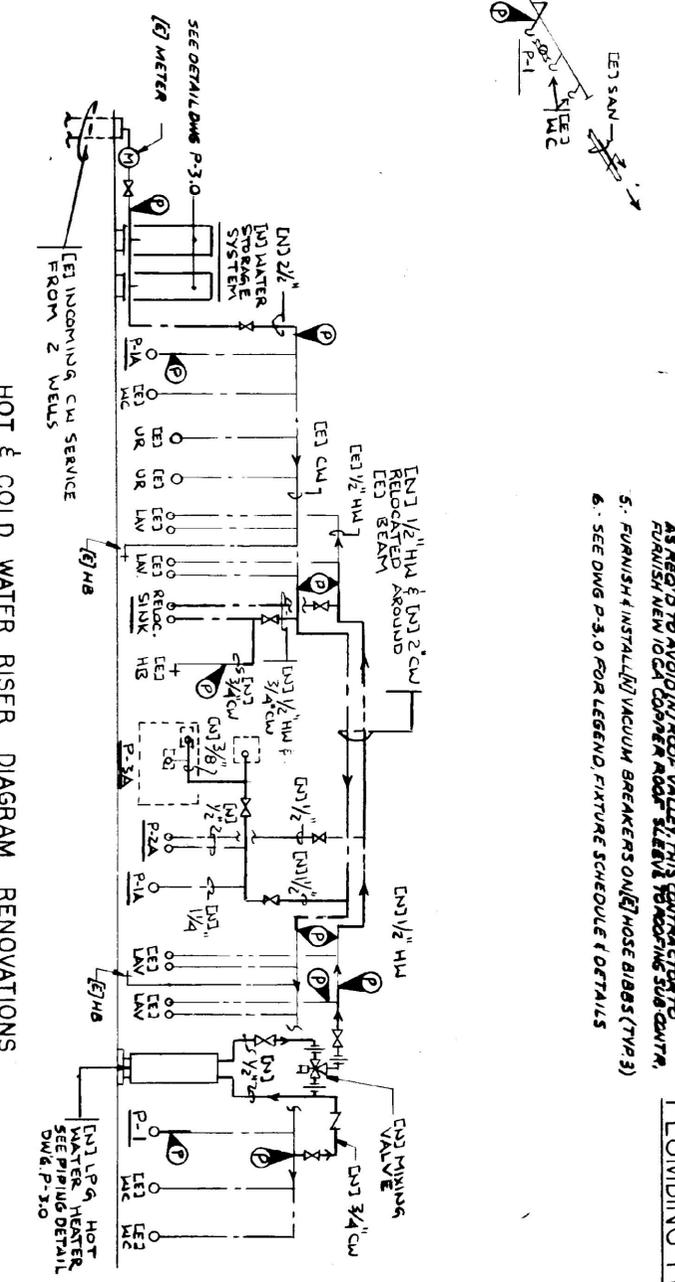

HOT & COLD WATER RISER DIAGRAM RENOVATIONS
NOT TO SCALE



| | |
|------------------------------------------------------------------------------------------------------|-------------------|
| RECORD DRAWING | |
| STATE OF VERMONT DEPARTMENT OF STATE BUILDINGS AGENCY OF ADMINISTRATION MONTPELIER, VERMONT | |
| REST AREA REHABILITATION GEORGIA I-89 NORTHBOUND | |
| DATE: 8-21-98 | SCALE: 1/4"=1'-0" |
| DRAWN BY: D.G. | PROJECT NO: 97-98 |
| CHECKED BY: M.F.L. | DRAWING NO: P-10 |
| DRAWING NAME: PLUMBING PLANS | |