



DEMOLITION - PLUMBING-EXISTING FLOOR PLAN
SCALE: 1/4"=1'-0"

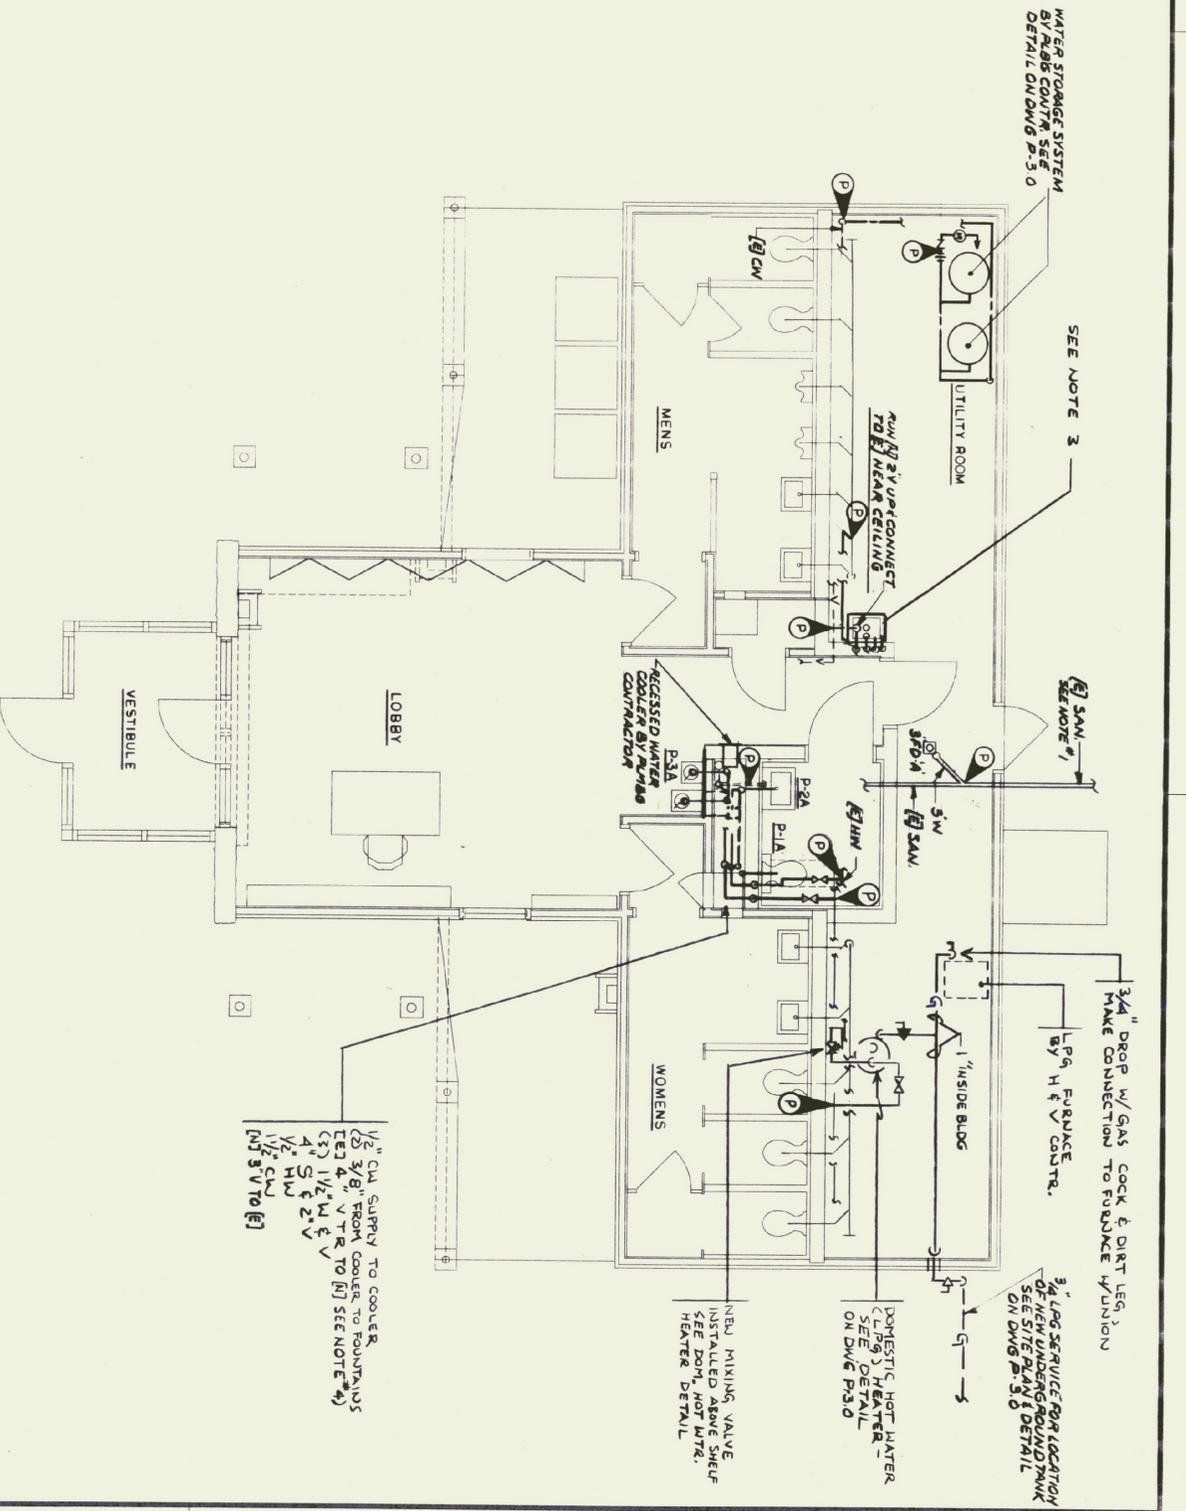


RENOVATION - PLUMBING-FLOOR PLAN
SCALE: 1/4"=1'-0"

- NOTES:**
1. THE UNDERFLOOR SANITARY SYSTEM PIPING IS ASSUMED TO BE APPROX. CORRECT HOWEVER THE PLUMBING SUB CONTRACTOR SHALL FIELD REPAIRS, HIS EXACT LOCATION PRIOR TO THE GENERAL CONTRACTOR BREAKING UP THE FLOOR.
 2. COORDINATE ALL WORK WITH EXISTING CONDITIONS & [N] WORK BY OTHER TRADES.
 3. RELOCATE [E] SINK W/ ALL [E] HOT & COLD WATER PIPING W/ SHUT-OFFS. VENT, WASTE W/ TRAP PIPING SYSTEMS. (PIPING SIZES TO [E]) FINISH & INSTALL [E] SUPPORT ANCHORS, BOLTS & NUTS AS REQUIRED. CONVERT PIPING SYSTEMS TO NEAREST ACTIVE LINES (SYSTEMS) IN AREA.
 4. EXTEND [E] VENT UP THRU NEW ROOF STRUCTURE & OFFSET 45 DEG. TO AVOID [E] ROOF VALLERY TRUS COUPLER. SET 1/2" NEW [E] ROOF COUPLER ROOF SLEEVE TO ROOFING SUB CONTRACTOR.
 5. SEE DWG P-3-0 FOR LEGEND, FIXTURE SCHEDULE & DETAILS.

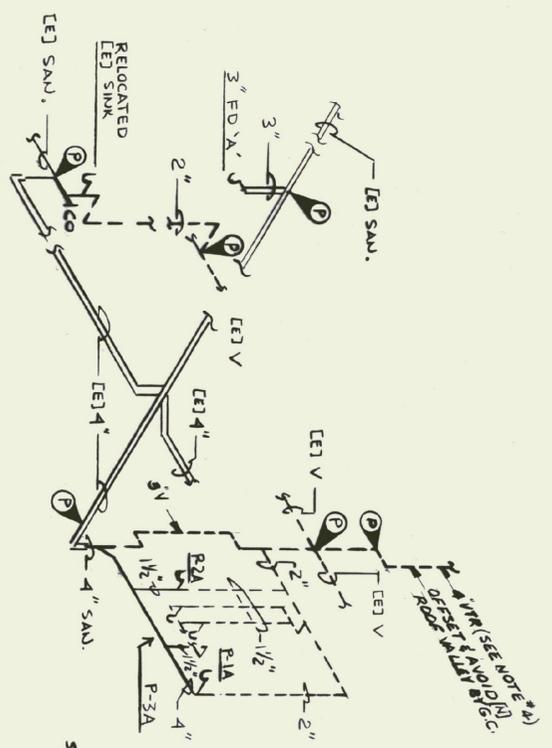

SANITARY & VENT ISOMETRIC DIAGRAM RENOVATIONS
NOT TO SCALE

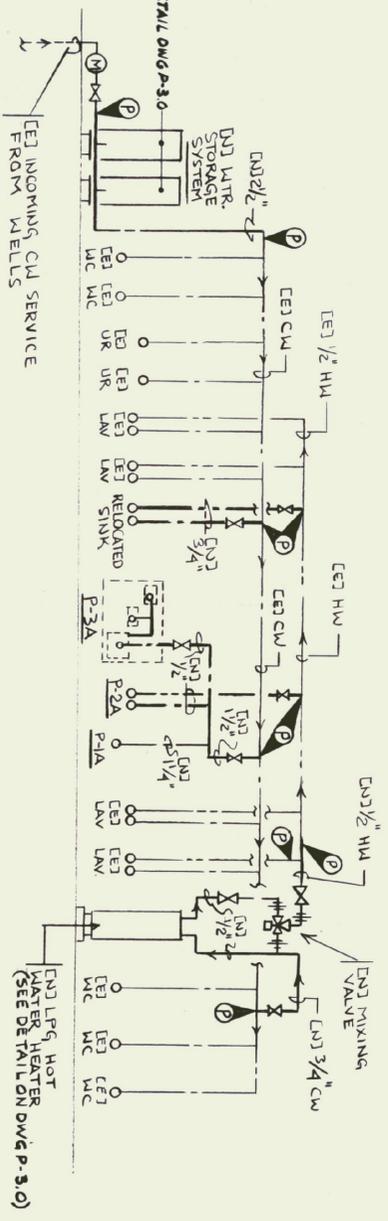

HOT & COLD WATER RISER DIAGRAM RENOVATIONS
NOT TO SCALE

STATE OF VERMONT
DEPARTMENT OF STATE BUILDINGS
AGENCY OF ADMINISTRATION
MONTPELIER, VERMONT

REST AREA REHABILITATION
GEORGIA I-89 SOUTHBOUND
PLUMBING - DEMOLITION & RENOVATION
FLOOR PLANS, SCHEDULE, DETAIL & LEGEND

RECORD DRAWING

DATE: 8-21-98
SCALE: 1/4"=1'-0"
DRAWING NO.: P-2.0

DRAWN BY: DG
APPROVED BY:
DRAWING NAME: SHEET