


**H & V
DEMOLITION
EXISTING FLOOR PLAN**
SCALE: 1/4"=1'-0"

EQUIPMENT SCHEDULE: FURNISH & INSTALL THE FOLLOWING

EXHAUST FAN #1 - UTILITY TYPE; SPLIT DRIVEN RATED @ 800 CFM @ 3" STATIC PRESS @ 90 RPM, 3 SPEED W/ 3/4 HP, 120V/1/2 HP MOTOR FAN BY GREENHECK CO. (SEE SPEC NOTE: INSTALL FAN DISCHARGE IN TIEBACK TO RUN ON OCCASION OF LOW FLOW (SEE SPEC NOTE: INSTALL FAN PRIOR TO INSTALLING THE SPEED) FOR FITTING INTO SPACE @ 800 CFM HIGH SPEED) (SEE SECTION A-A FOR SPEED)

GAS FIRED MAKE - GAS FIRED FURNACE RATED @ 125 MBH LG INPUT, 100 MBH OUTPUT, 1680 CFM @ 5" STATIC PRESS, 3/4 HP, 120V/1/2 HP MOTOR W/ 4 MIN. SPEED SETTINGS WIRED TO MH SETTING, FURNISH W/ INT. DAMPER & FILTER, UNIT BY THERMO PRIDE. HIGHWAY SECTIONAL GAS FURNACE MODEL NO. 1M4-125 (SEE SPEC.)

RENOVATION-H & V FLOOR PLAN
SCALE: 1/4"=1'-0"

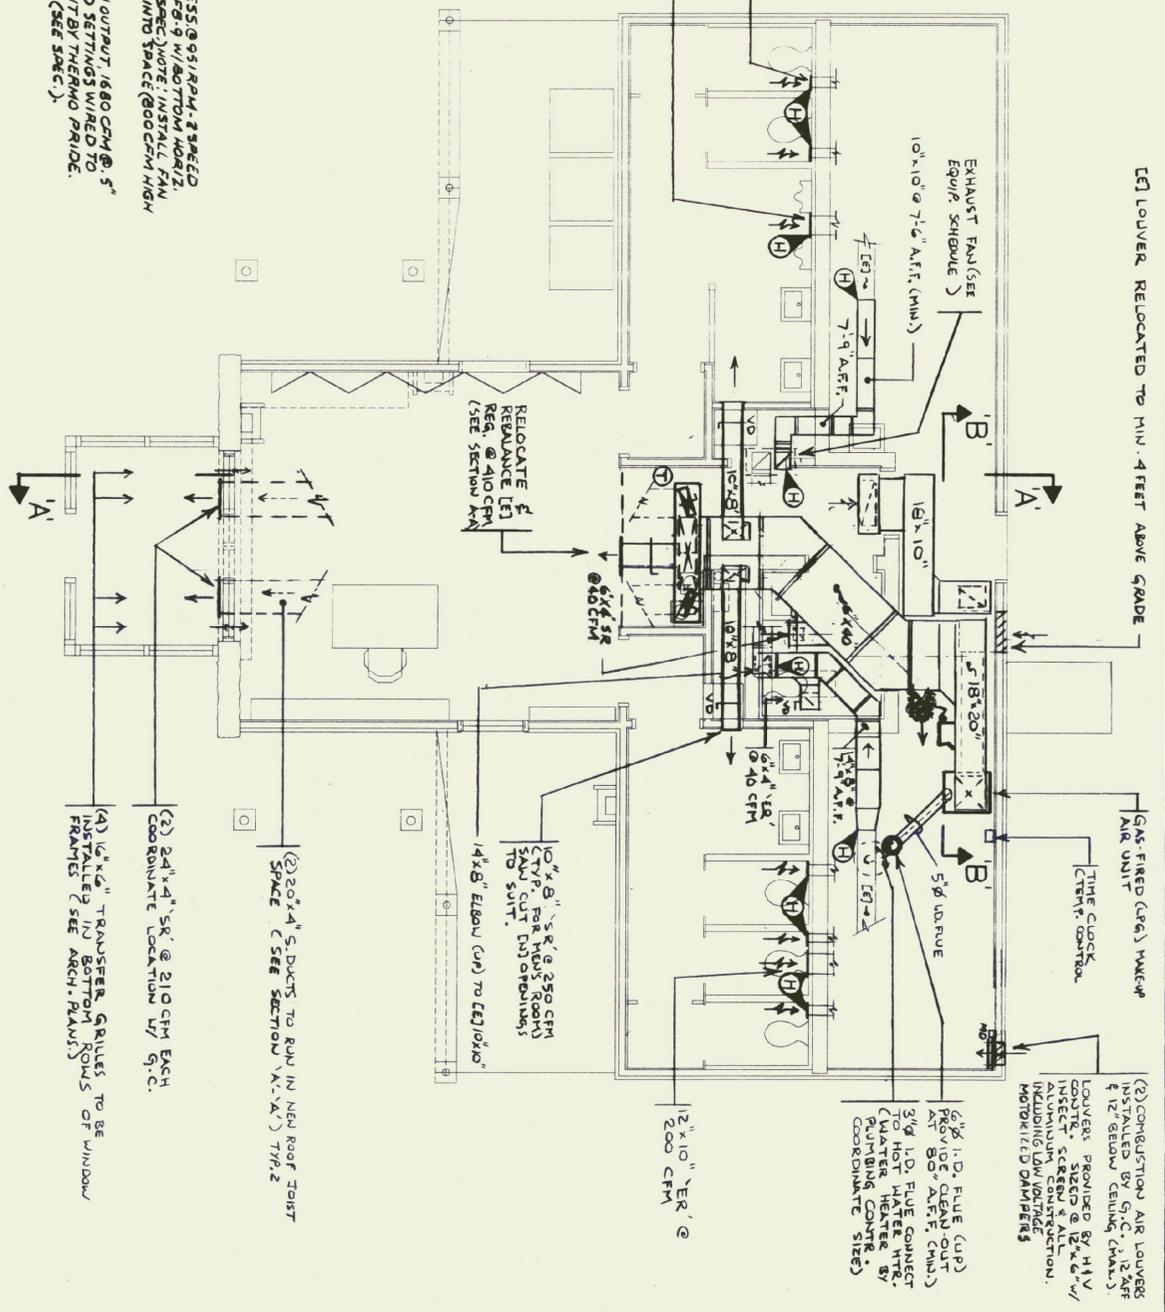

H & V LEGEND	
N	NEW
E	EXISTING
XXXXXX	EXISTING TO BE REMOVED
—H—	TRANSFER GRILLE
—P—	POINT OF CONNECTION
—S—	AIR SUPPLY
—E—	AIR EXHAUST
—VD—	VOLUME DAMPER
—MD—	MOTORIZED DAMPER
—AFF—	ABOVE FINISH
—ER—	EXHAUST REGISTER
—SR—	SUPPLY DAMPER


RECORD DRAWING

STATE OF VERMONT
DEPARTMENT OF STATE BUILDINGS
AGENCY OF ADMINISTRATION
MONTPELIER, VERMONT

REST AREA REHABILITATION
GEORGIA - I-89 SOUTHBOUND
HEATING & VENTILATING - DEMOLITION
& RENOVATION FLOOR PLANS & DETAILS

DATE:	8-21-98	SCALE:	1/4"=1'-0"	REVISIONS:		DRAWING NO.:	H-2.0
DRAWN BY:	KA DC	APPROVED BY:	NEL	DRAWING NAME:	HEATING & VENTILATING & RENOVATION FLOOR PLANS & DETAILS	SHEET:	OF

SECTION 'A'- 'A'
SCALE: 1/4"=1'-0"

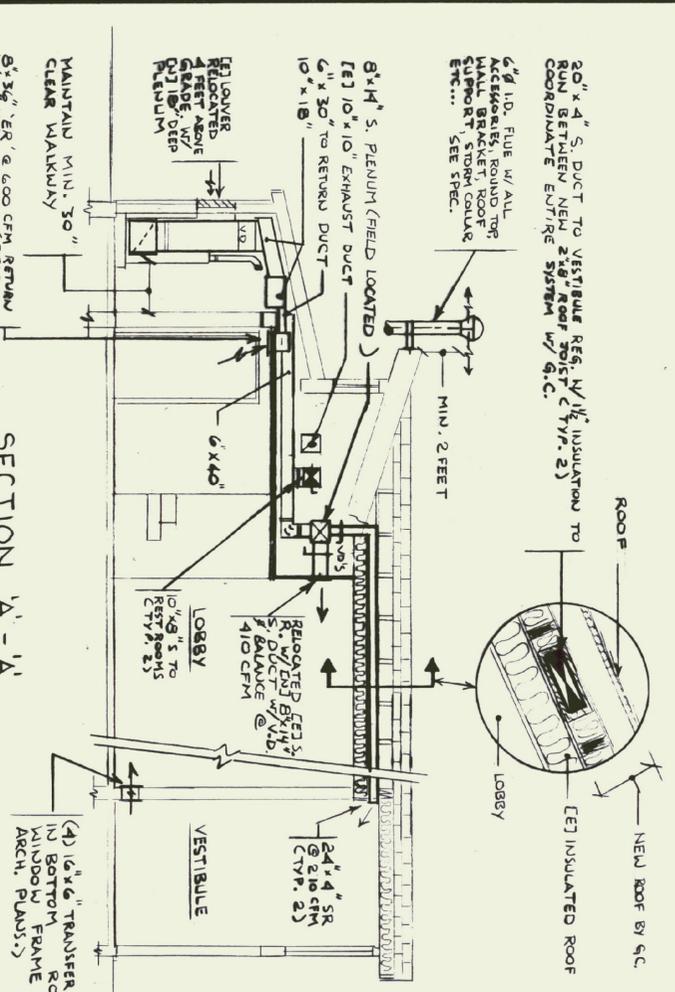

SECTION 'B'- 'B'
SCALE: 1/4"=1'-0"

